


EXISTING PLAN

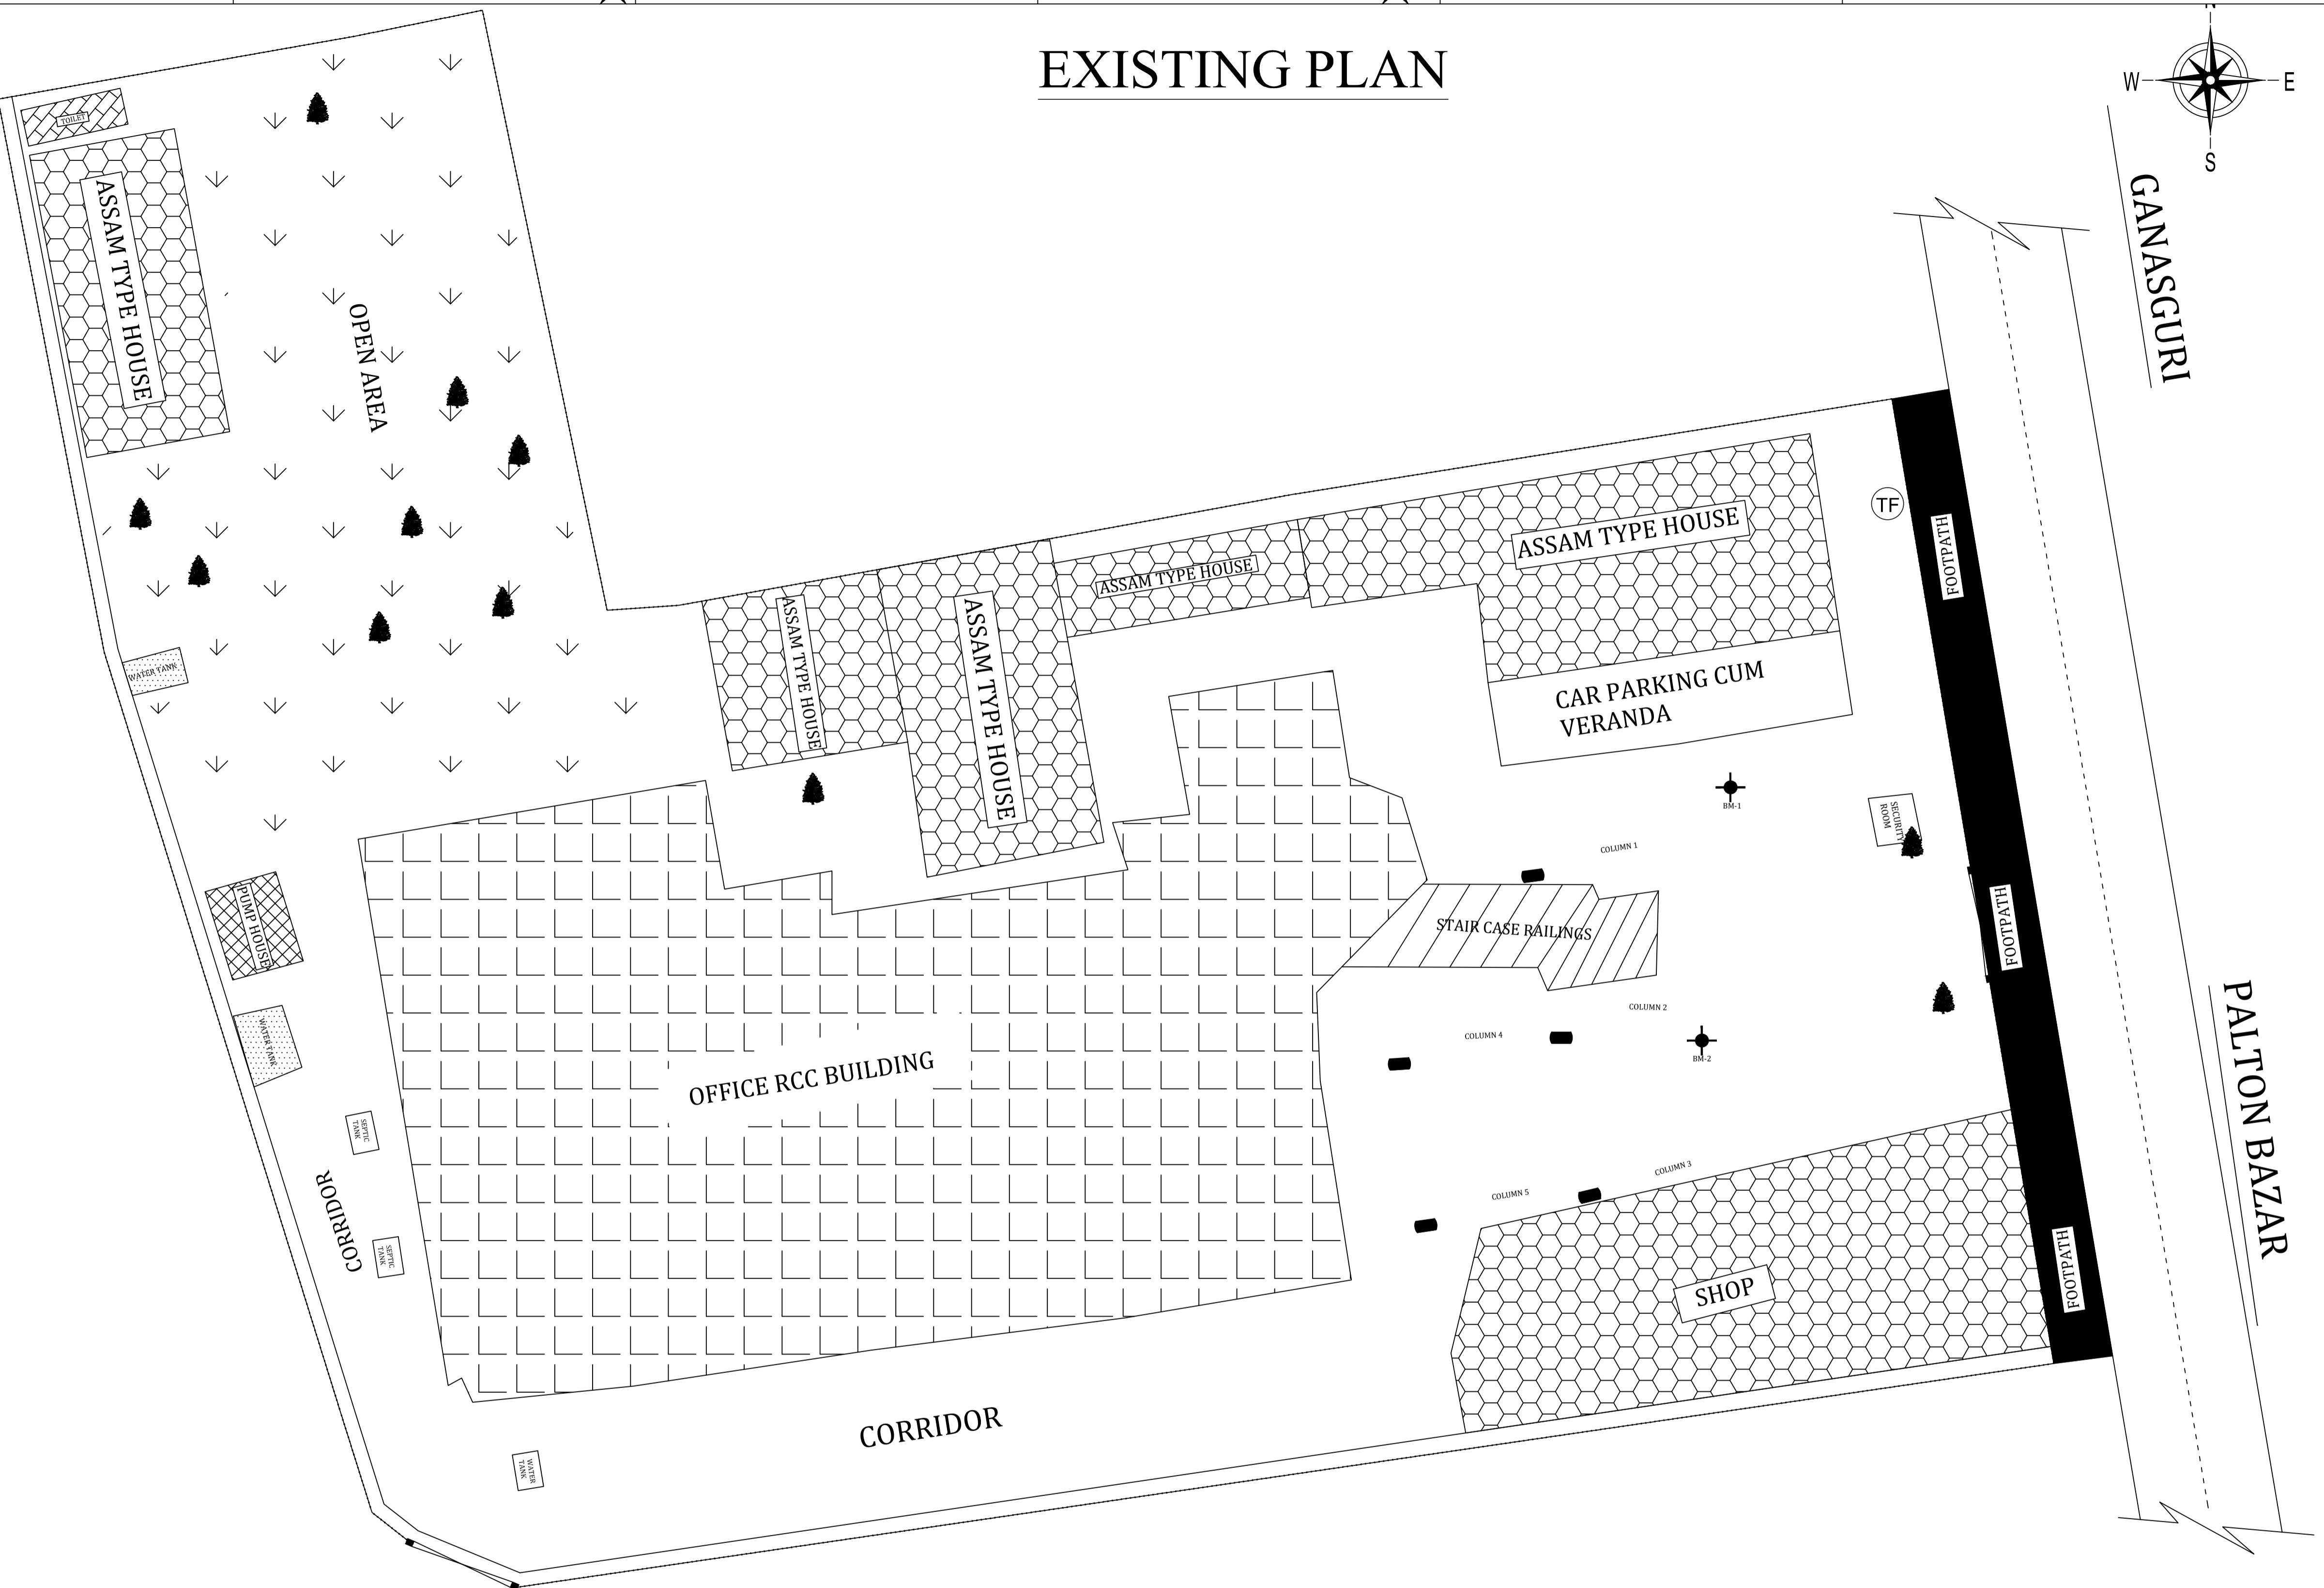

Name of Work :-

Assam Inland Water Transport Development Project.

BM 1		BM 2		LEGEND :	
NORTHING	2895586.770	NORTHING	2895594.650	BM PILLAR	
EASTING	375950.452	EASTING	375945.701	GS ROAD	
ELEVATION	52.178	ELEVATION	52.315	EXISTING STRUCTURE	
				FOOTPATH	
				EXISTING BOUNDARY WALL	
				TREE	
				TRANSFORMER	
				EXISTING OPEN DRAIN	

Drawing No.: A01

Scale:

AREA:- 2586.45 sqm

CONSULTANT:



Consultant by
BASIC CONSULTANT
Engineers & Consultants

CLIENT

Assam Inland Water Transport Development Society.

Architectural and engineering services for setting-up of office of Assam Inland Water Transport Regulatory Authority (AIWTRA) & Office of Assam Inland Water Company Ltd. (AIWCL) at directorate of IWT'S existing office building premises at Ulubari, Guwahati (Assam).

GENERAL NOTES:

1. ALL DIMENSIONS ARE IN MILLIMETERS AND LEVELS IN METERS.
2. THIS DRAWING IS NOT TO BE SCALED, FOLLOW WRITTEN DIMENSIONS.
3. ANY DISCREPANCY SHALL FIRST BE CLARIFIED WITH THE CONSULTANT/ARCHITECT BEFORE PROCEEDING ANY FURTHER.

PROJECT
Assam Inland Water Transport Development Project.

DRAWING TITLE EXISTING PLAN SITE PLAN

DISCIPLINE: RENOVATION

STATUS DPR

FILE NAME:

DESIGNED:	dhruv	DRAWN:	samrat	NORTH
APPROVED:	concerned	CHECKED:	dhruv	
DATE:	30/08/23	SCALE	1:150	
GOV. 22/02	A-01		R-00	

A1 DRAWINGS

1
E
D
C
B
A

2

3

4

5


6

7

Name of Work :-

Assam Inland Water Transport Development Project.

DEMOLISHING PLAN

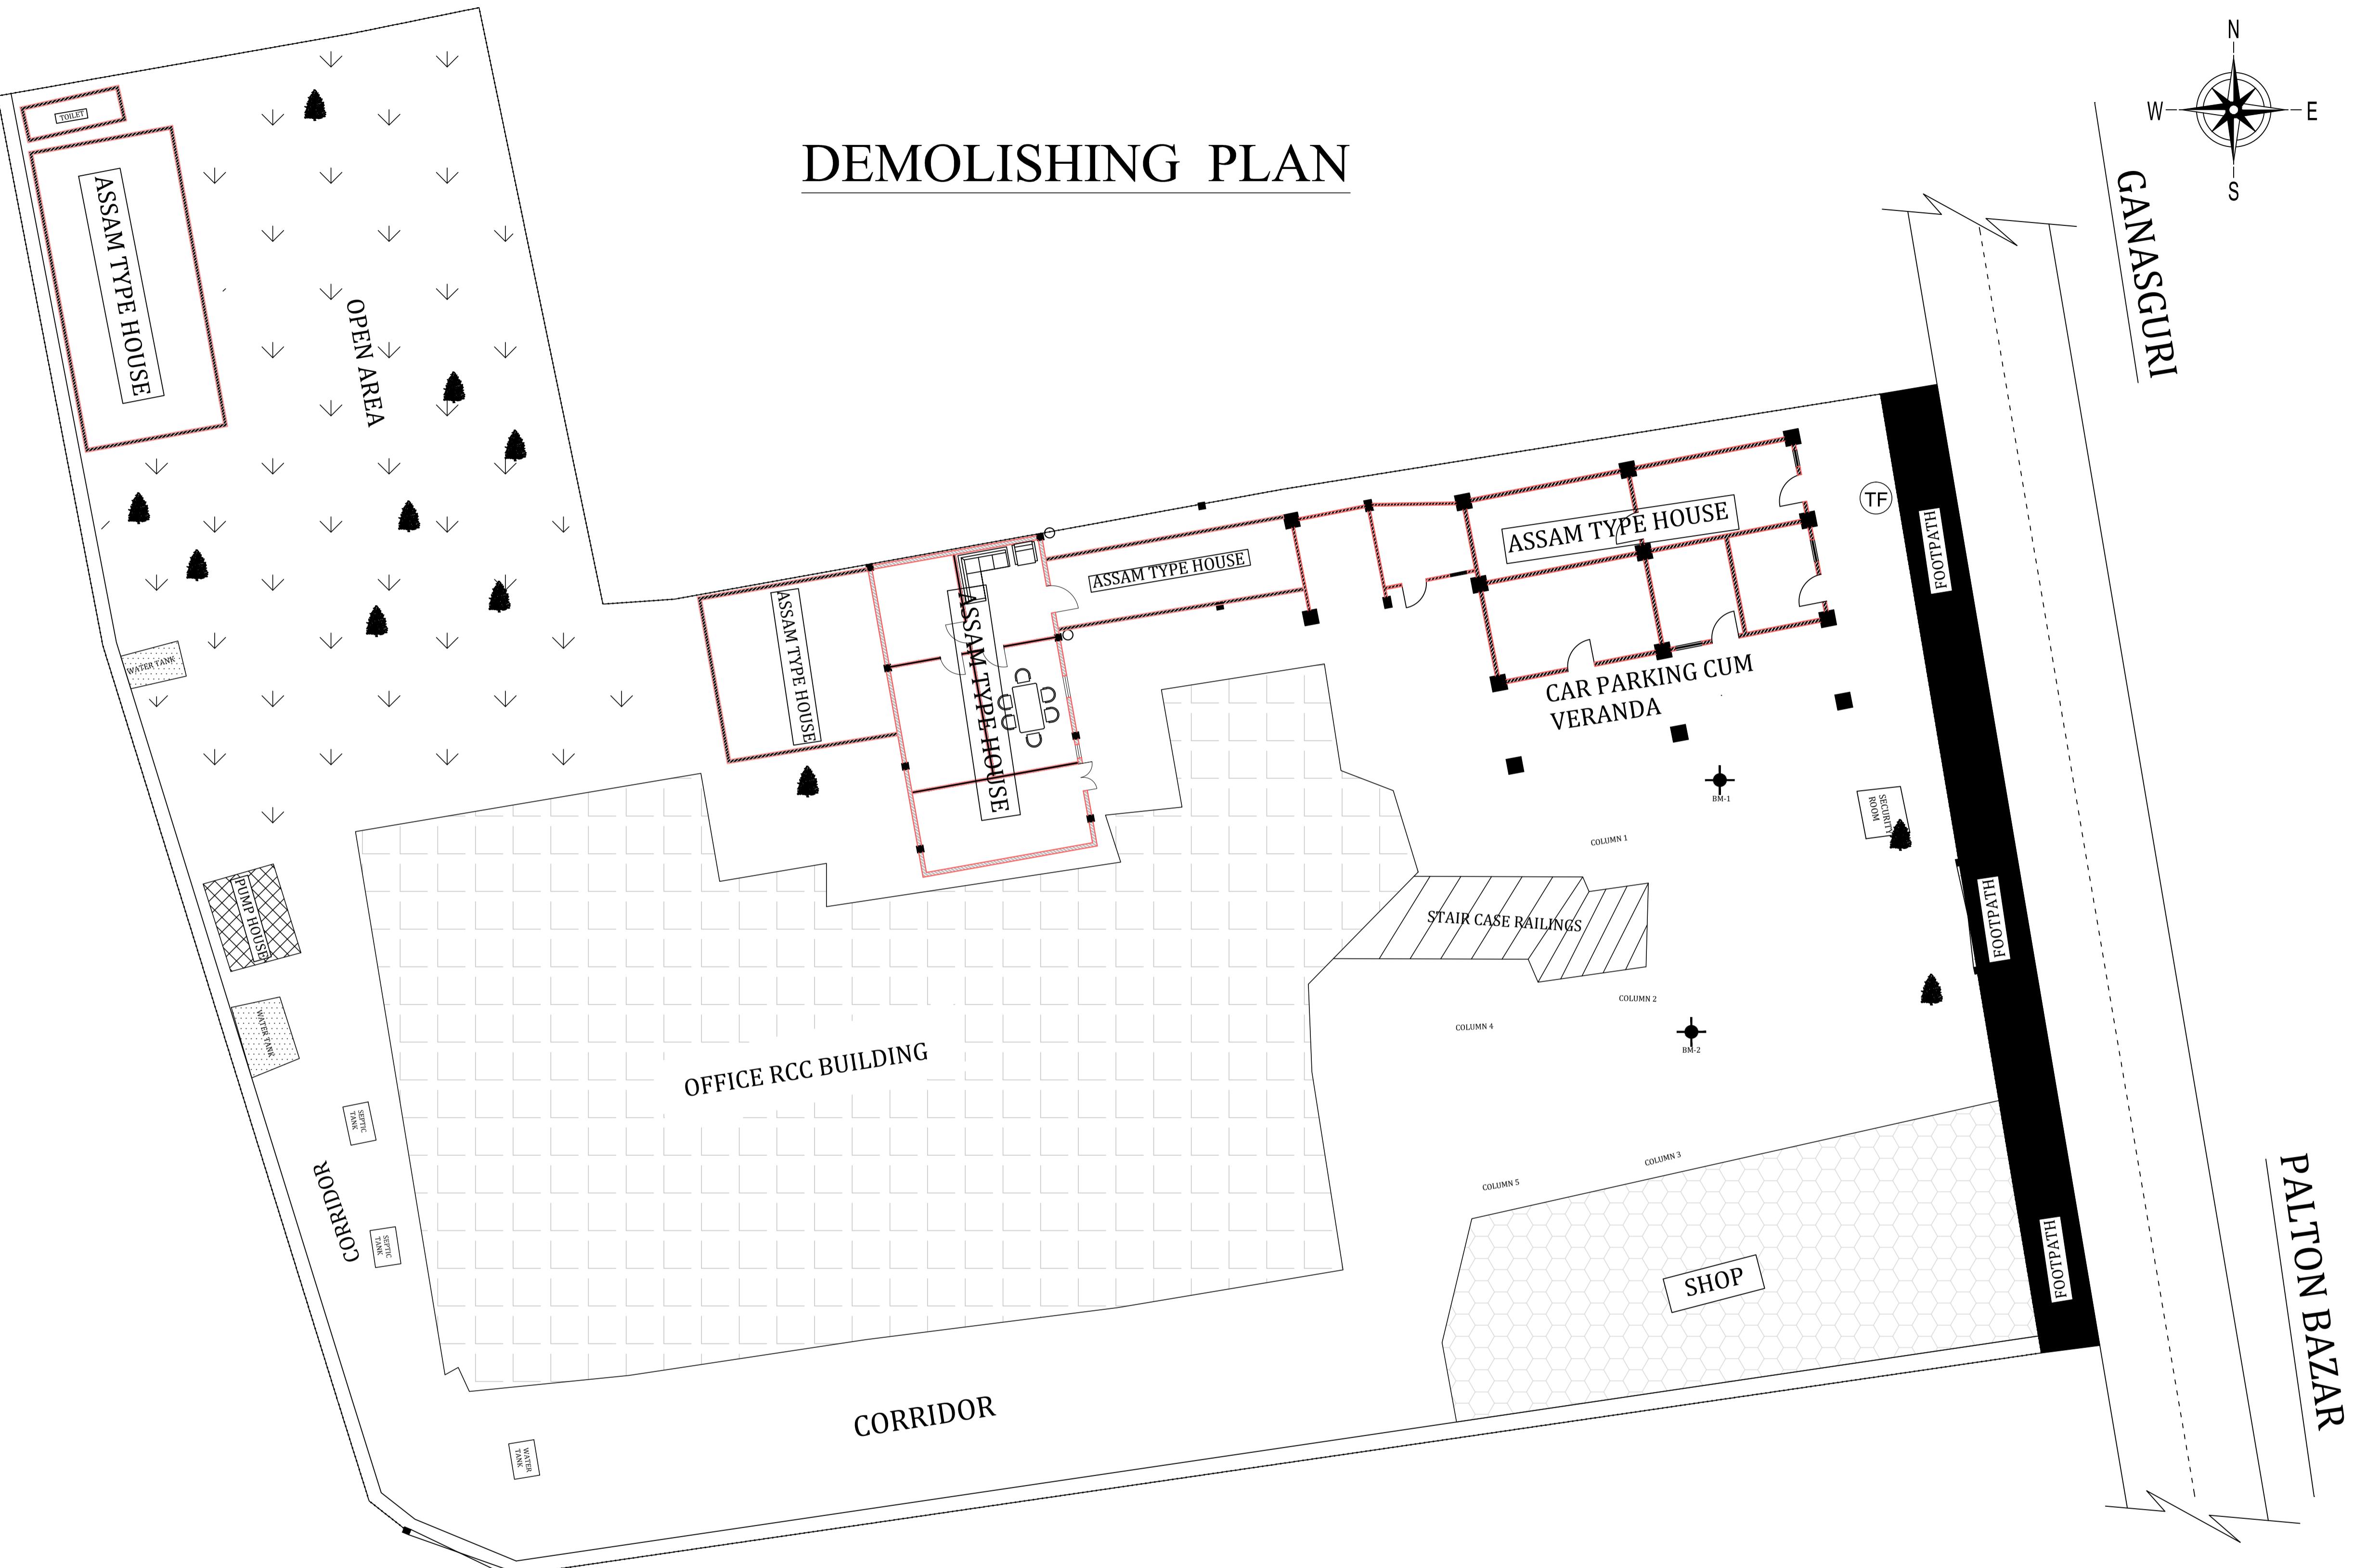

LEGEND :	
BRICK WALLS	BM 1 NORTHING EASTING ELEVATION
PARTITION	NORTHING EASTING ELEVATION
RCC COLUMN	2895586.770 375950.452 52.178

LEGEND :	
BM PILLAR	BM 2 NORTHING EASTING ELEVATION
GS ROAD	2895594.650 375945.701 52.315
EXISTING STRUCTURE	
FOOTPATH	
EXISTING BOUNDARY WALL	
TREE	
TRANSFORMER	TF
EXISTING OPEN DRAIN	

Drawing No.: A02

Scale:

AREA:- 2586.45 sqm

© ANTRÉ BOURGEON LLP. (A3 sheet - 420x297)

CONSULTANT:



Consultant by
BASIC CONSULTANT
Engineers & Consultants

CLIENT

Assam Inland Water Transport
Development Society.

Architectural and engineering services
for setting-up of office of Assam Inland
Water Transport Regulatory Authority
(AIWTRA) & Office of Assam Inland
Water Company Ltd. (AIWCL) at
directorate of IWT'S existing office
building premises at Ulubari, Guwahati
(Assam).

GENERAL NOTES:

1. ALL DIMENSIONS ARE IN MILLIMETERS
AND LEVELS IN METERS.
2. THIS DRAWING IS NOT TO BE SCALED,
FOLLOW WRITTEN DIMENSIONS.
3. ANY DISCREPANCY SHALL FIRST BE
CLARIFIED WITH THE
CONSULTANT/ARCHITECT BEFORE
PROCEEDING ANY FURTHER.

PROJECT

Assam Inland Water
Transport Development
Project.

**EXISTING PLAN
DEMOLISHING PLAN**


DISCIPLINE: RENOVATION

STATUS DPR

FILE NAME:

DESIGNED: dhruv	DRAWN: samrat	NORTH W E S N
APPROVED: concerned	CHECKED: dhruv	
DATE: 30/08/23	SCALE 1:150	
GOV. 22/02	A-02	R-00


A1 DRAWINGS

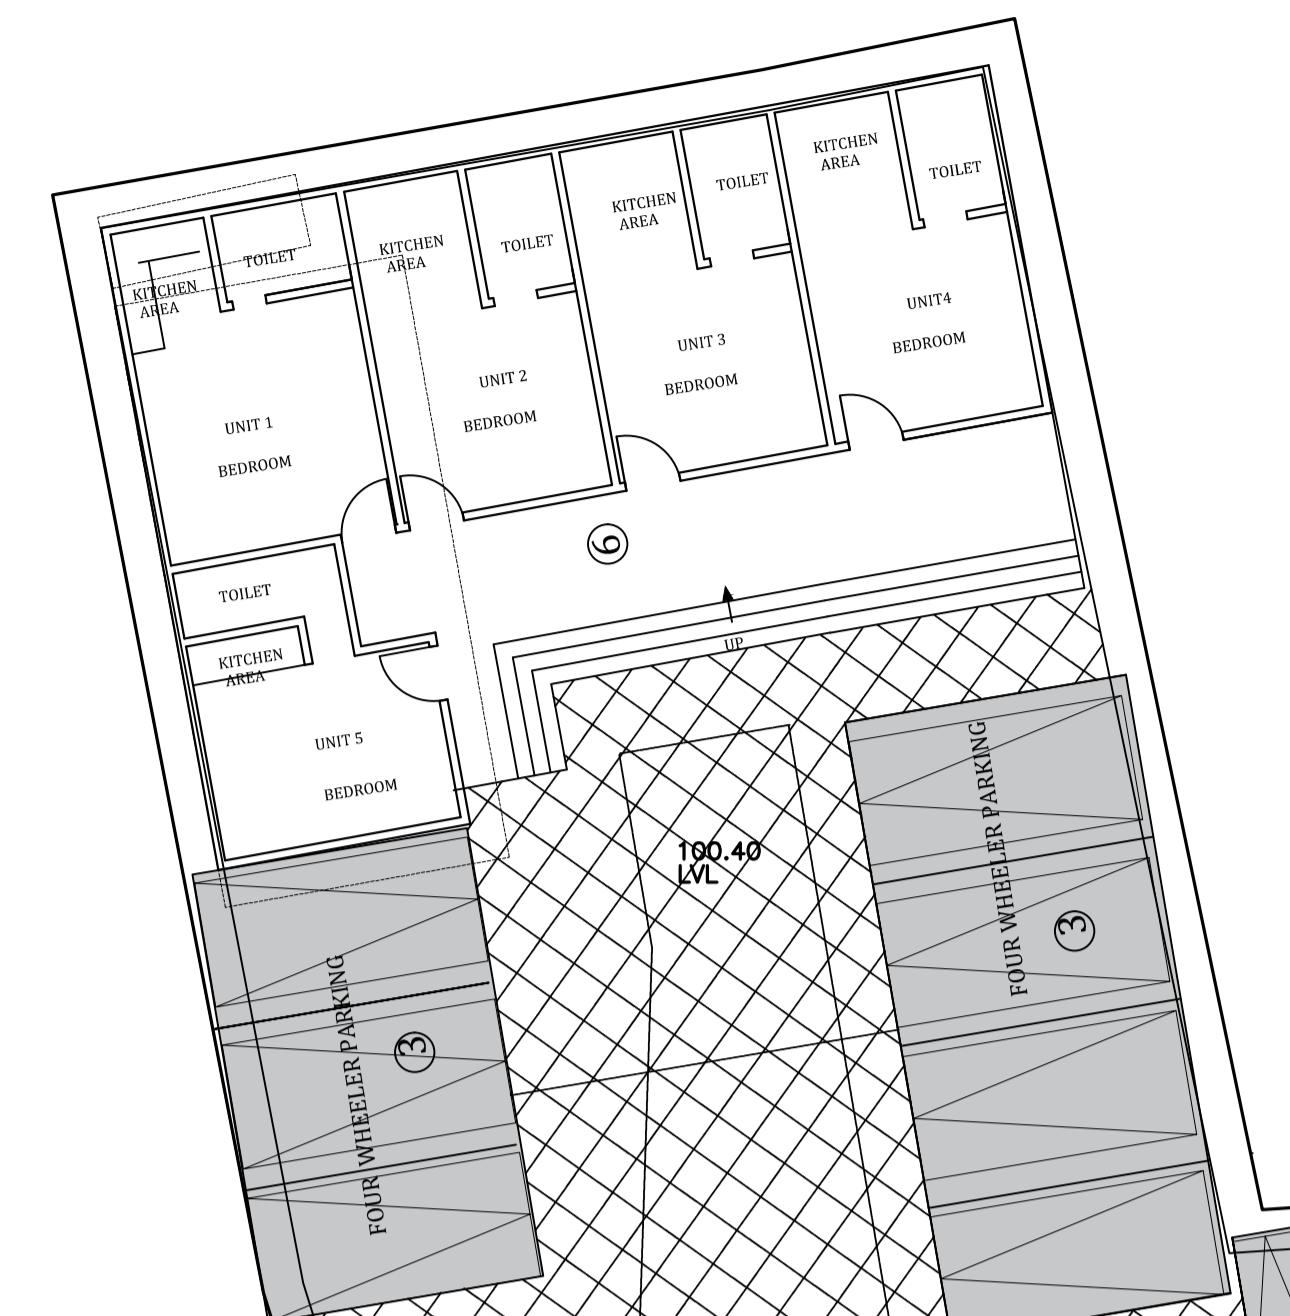

OFFICE RCC BUILDING

LEGEND:-

- 1 ENTRY
- 2 SECURITY ROOM
- 3 FOUR WHEELER PARKING
- 4 TWO WHEELER PARKING
- 5 LANDSCAPE AREA
- 6 ASSAM TYPE HOUSE
- 7 EXIT

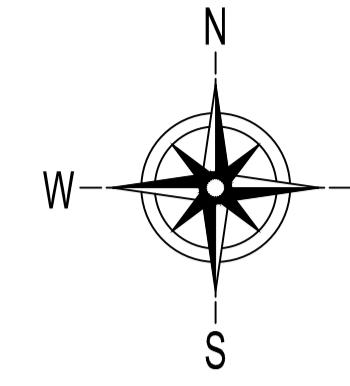

GANASGURI

PALTAN BAZAR

BM 1	BM 2	
NORTHING	2895586.770	NORTHING
EASTING	375950.452	EASTING
ELEVATION	52.178	ELEVATION

Drawing No.:		A03
Scale:		
AREA:-	2586.45 sqm	

Name of Work :-

Assam Inland Water Transport Development Project.

CONSULTANT:



Consultant by
BASIC CONSULTANT
Engineers & Consultants

CLIENT

Assam Inland Water Transport Development Society.

Architectural and engineering services for setting-up of office of Assam Inland Water Transport Regulatory Authority (AIWTRA) & Office of Assam Inland Water Company Ltd. (AIWCL) at directorate of IWT'S existing office building premises at Ulubari, Guwahati (Assam).

GENERAL NOTES:

1. ALL DIMENSIONS ARE IN MILLIMETERS AND LEVELS IN METERS.
2. THIS DRAWING IS NOT TO BE SCALED, FOLLOW WRITTEN DIMENSIONS.
3. ANY DISCREPANCY SHALL FIRST BE CLARIFIED WITH THE CONSULTANT/ARCHITECT BEFORE PROCEEDING ANY FURTHER.

PROJECT

Assam Inland Water Transport Development Project.

DRAWING TITLE
PROPOSED PLAN
SITE PLAN

DISCIPLINE: RENOVATION


STATUS DPR

FILE NAME:

DESIGNED:	dhruv	DRAWN:	samrat	NORTH
APPROVED:	concerned	CHECKED:	dhruv	
DATE:	30/08/23	SCALE	1:150	

GOV. 22/02 A-01 R-00

A1 DRAWINGS

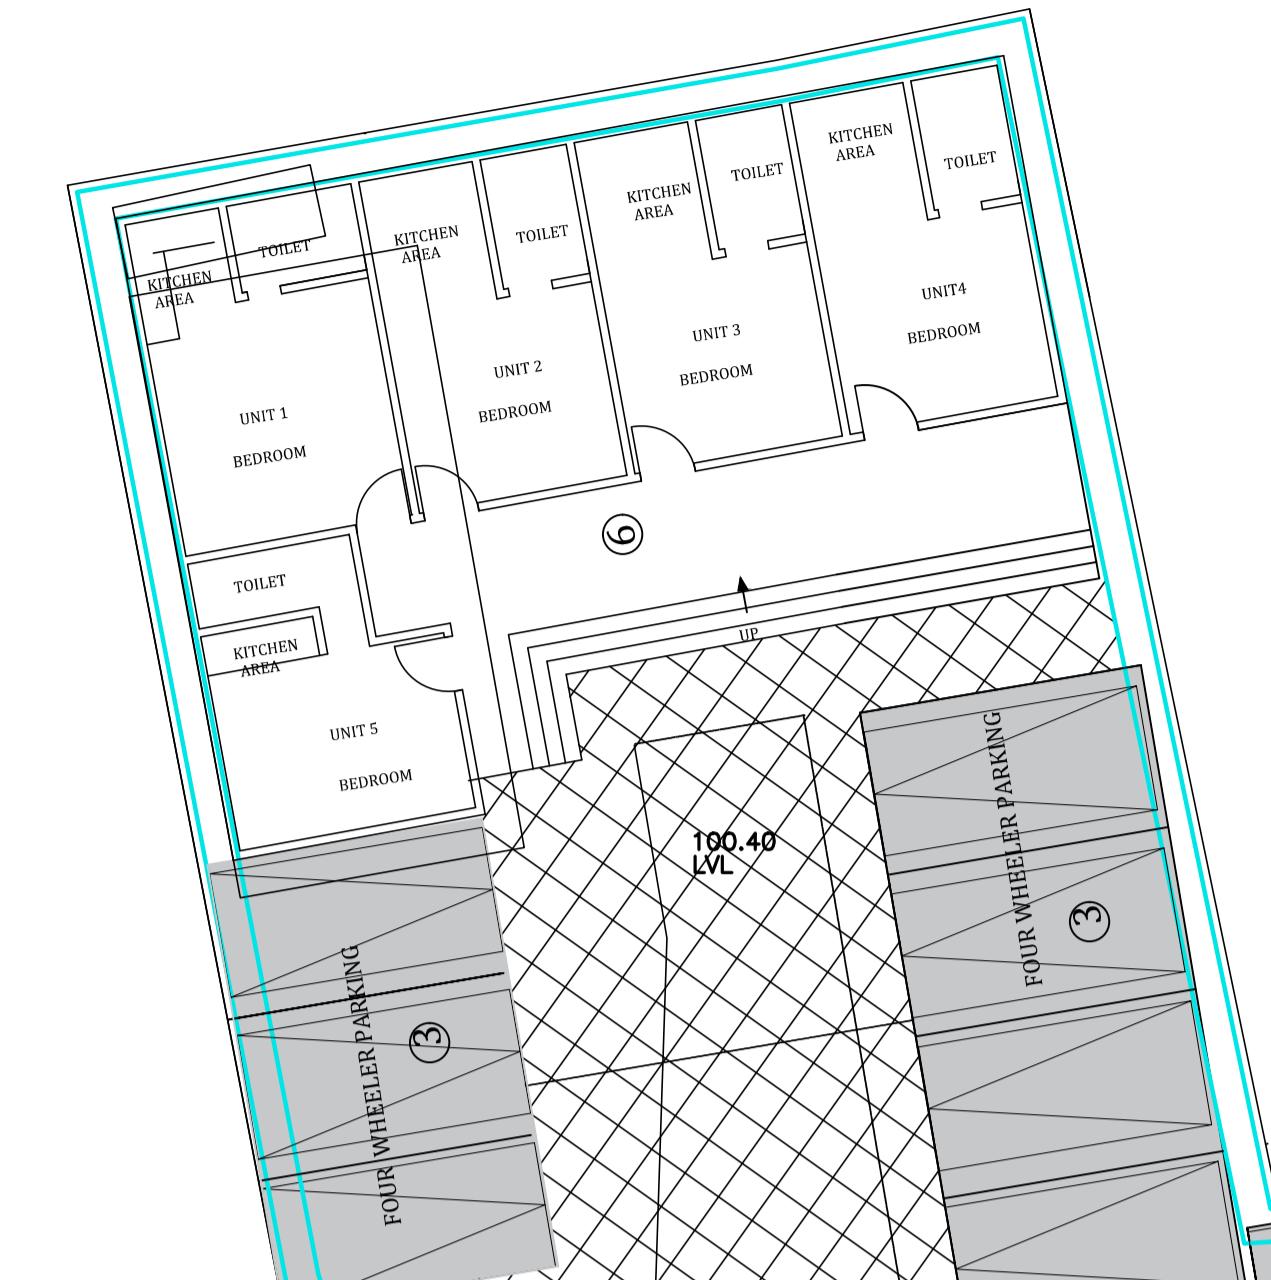


OFFICE RCC BUILDING

LEGEND:-

- 1 ENTRY
- 2 SECURITY ROOM
- 3 FOUR WHEELER PARKING
- 4 TWO WHEELER PARKING
- 5 LANDSCAPE AREA
- 6 ASSAM TYPE HOUSE
- 7 EXIT

Name of Work :-

Assam Inland Water Transport Development Project.

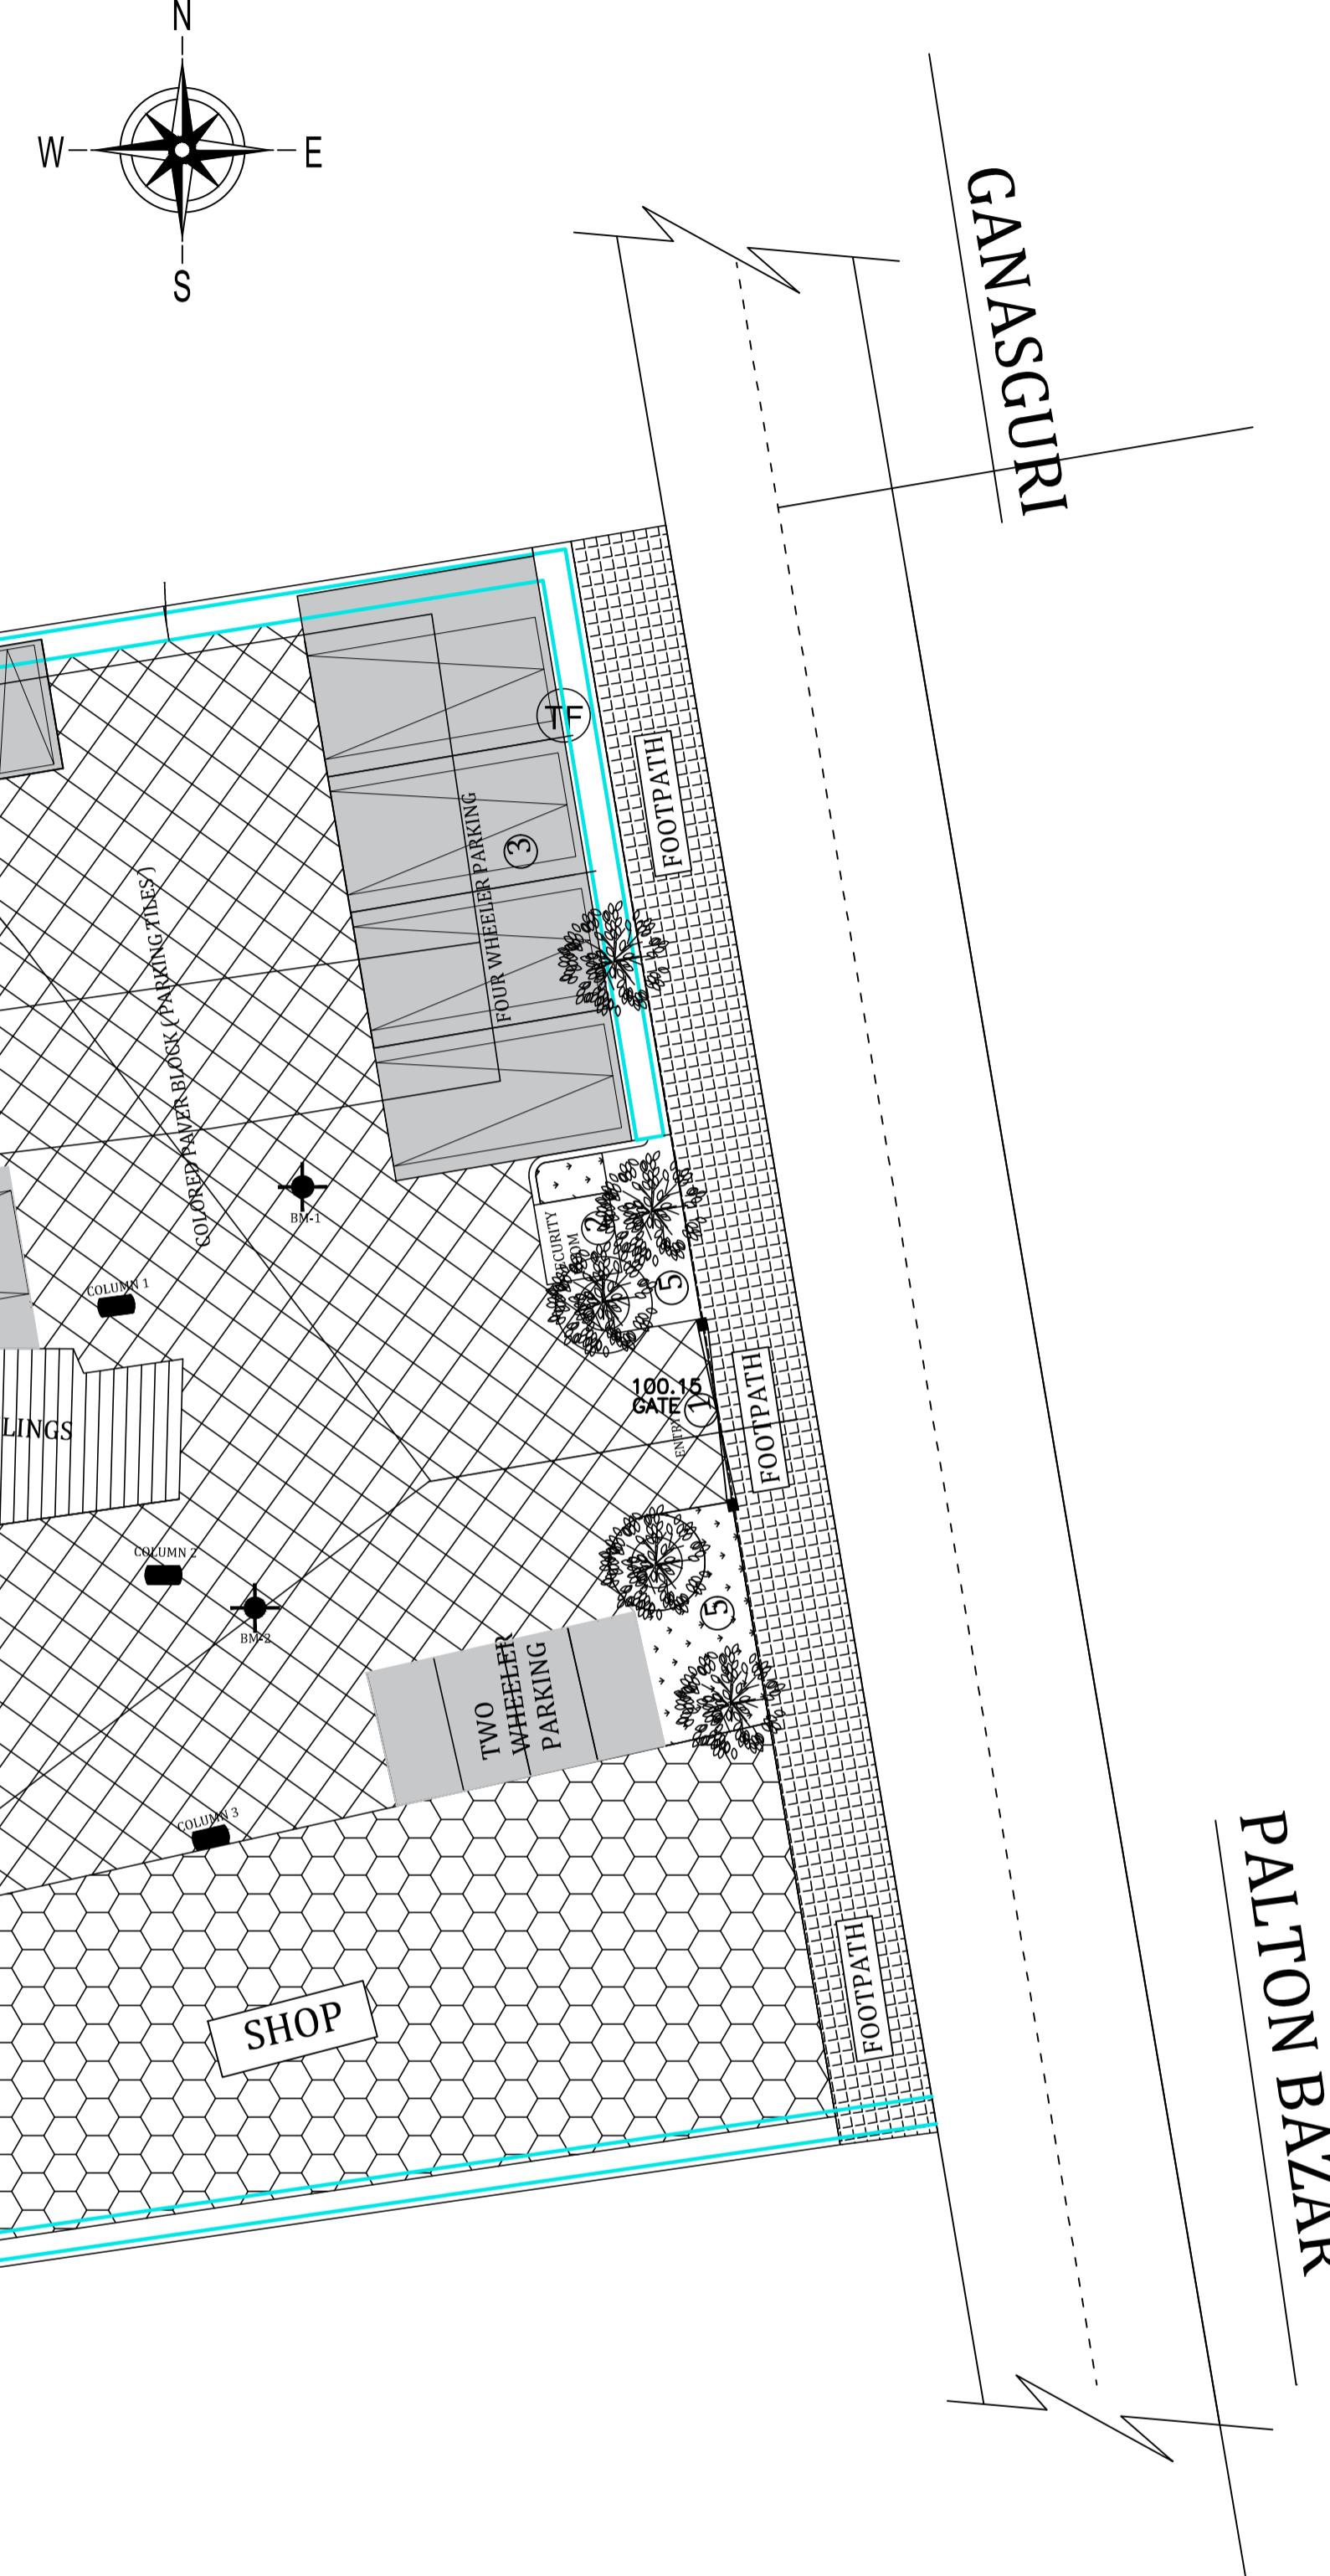

Drawing No.:

A04

Scale:

AREA:-

2586.45 sqm

© ANTRÉ BOURGEON LLP. (A3 sheet - 420x297)

CONSULTANT:



Consultant by
BASIC CONSULTANT
Engineers & Consultants

CLIENT

Assam Inland Water Transport Development Society.

Architectural and engineering services for setting-up of office of Assam Inland Water Transport Regulatory Authority (AIWTRA) & Office of Assam Inland Water Company Ltd. (AIWCL) at directorate of IWT'S existing office building premises at Ulubari, Guwahati (Assam).

GENERAL NOTES:

1. ALL DIMENSIONS ARE IN MILLIMETERS AND LEVELS IN METERS.
2. THIS DRAWING IS NOT TO BE SCALED, FOLLOW WRITTEN DIMENSIONS.
3. ANY DISCREPANCY SHALL FIRST BE CLARIFIED WITH THE CONSULTANT/ARCHITECT BEFORE PROCEEDING ANY FURTHER.

PROJECT

Assam Inland Water Transport Development Project.

**PROPOSED PLAN
DRAINAGE PLAN**

DISCIPLINE: RENOVATION

STATUS DPR


FILE NAME:



DESIGNED:	dhruv	DRAWN:	samrat	NORTH
APPROVED:	concerned	CHECKED:	dhruv	
DATE:	30/08/23	SCALE	1:150	
GOV. 22/02	A-04		R-00	

LEGEND :

PARKING	
PAVERS BLOCK	
FOOTPATH	
EXISTING BOUNDARY WALL	
TREE	
TRANSFORMER	
OPEN DRAIN	

A1 DRAWINGS

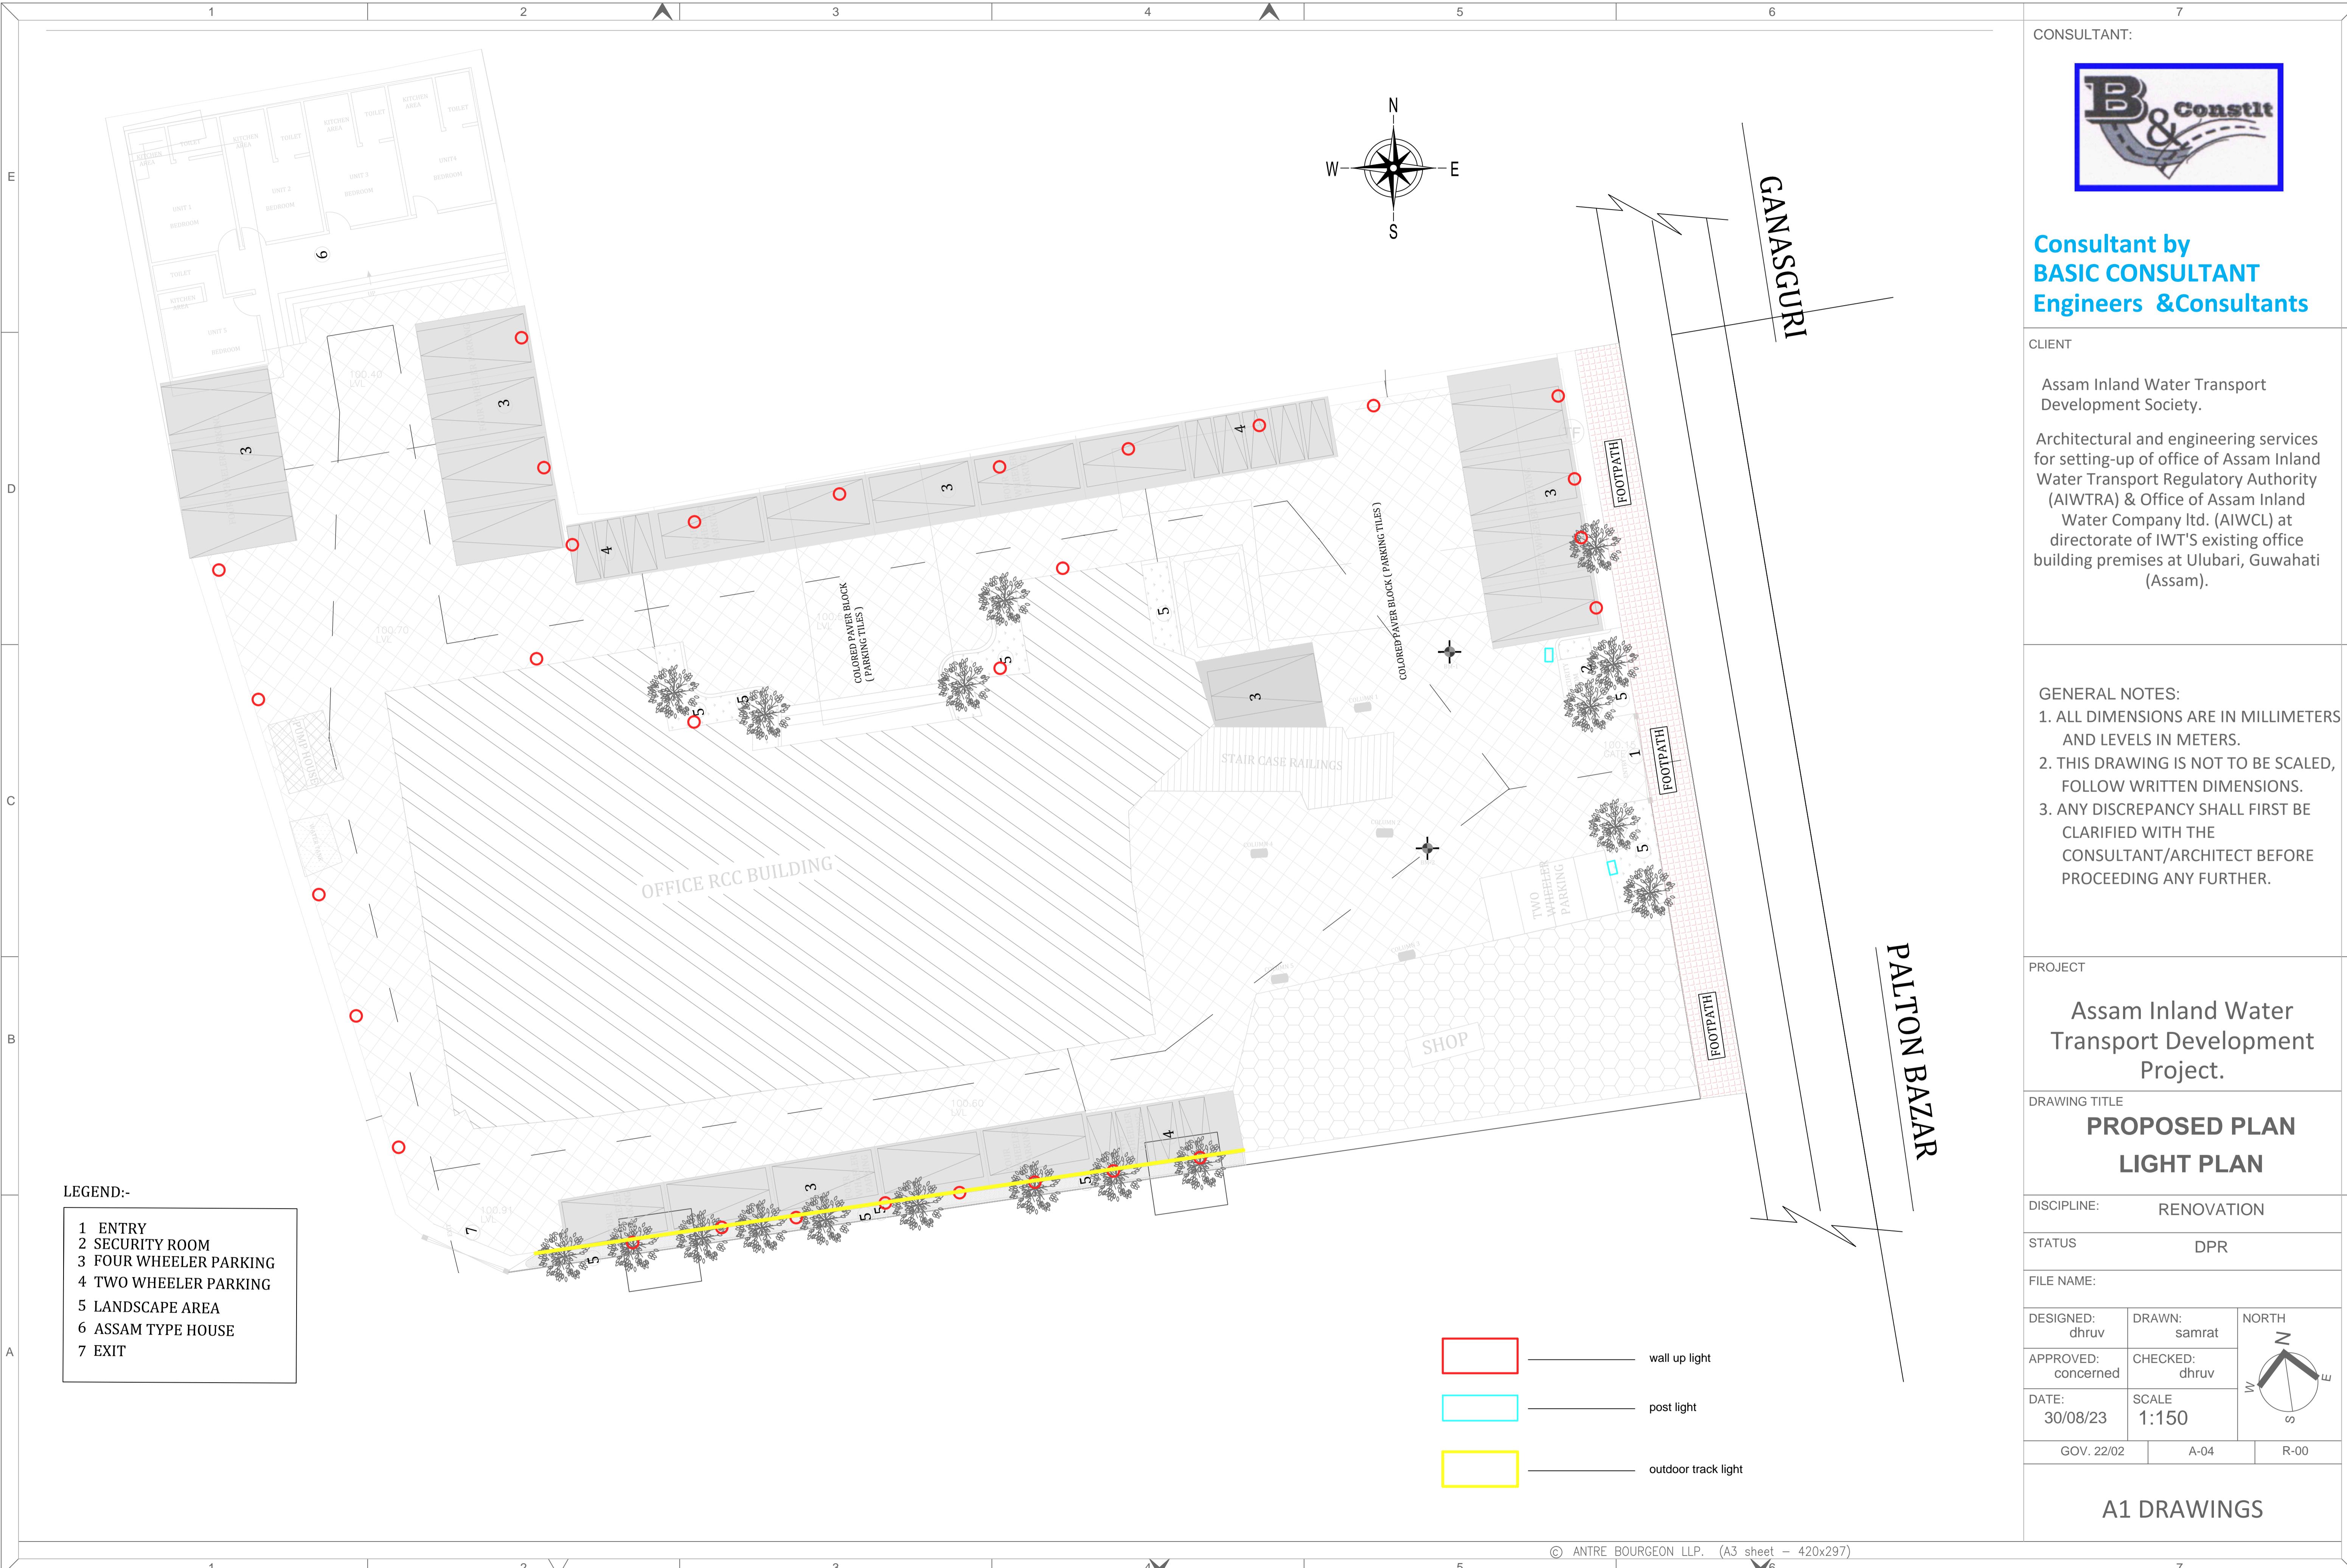

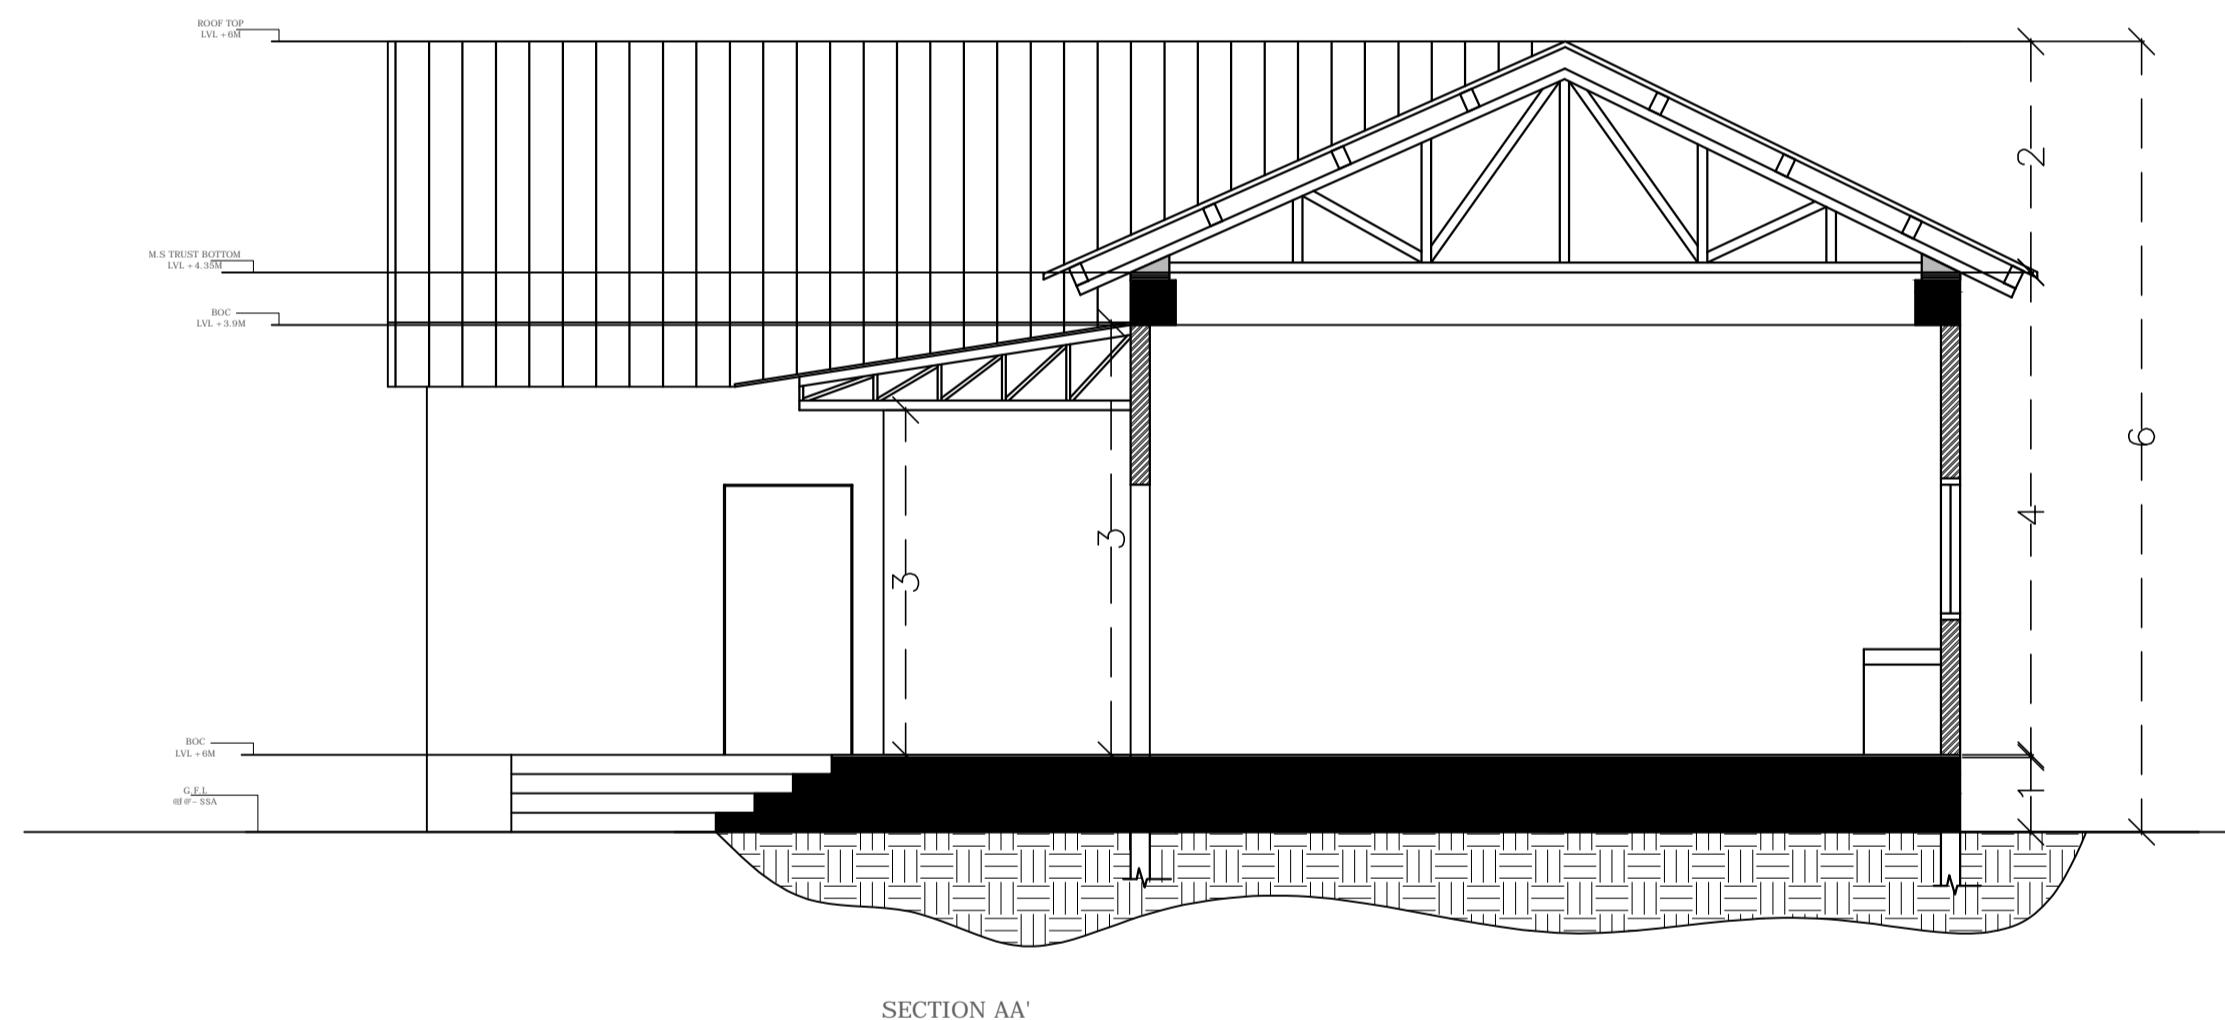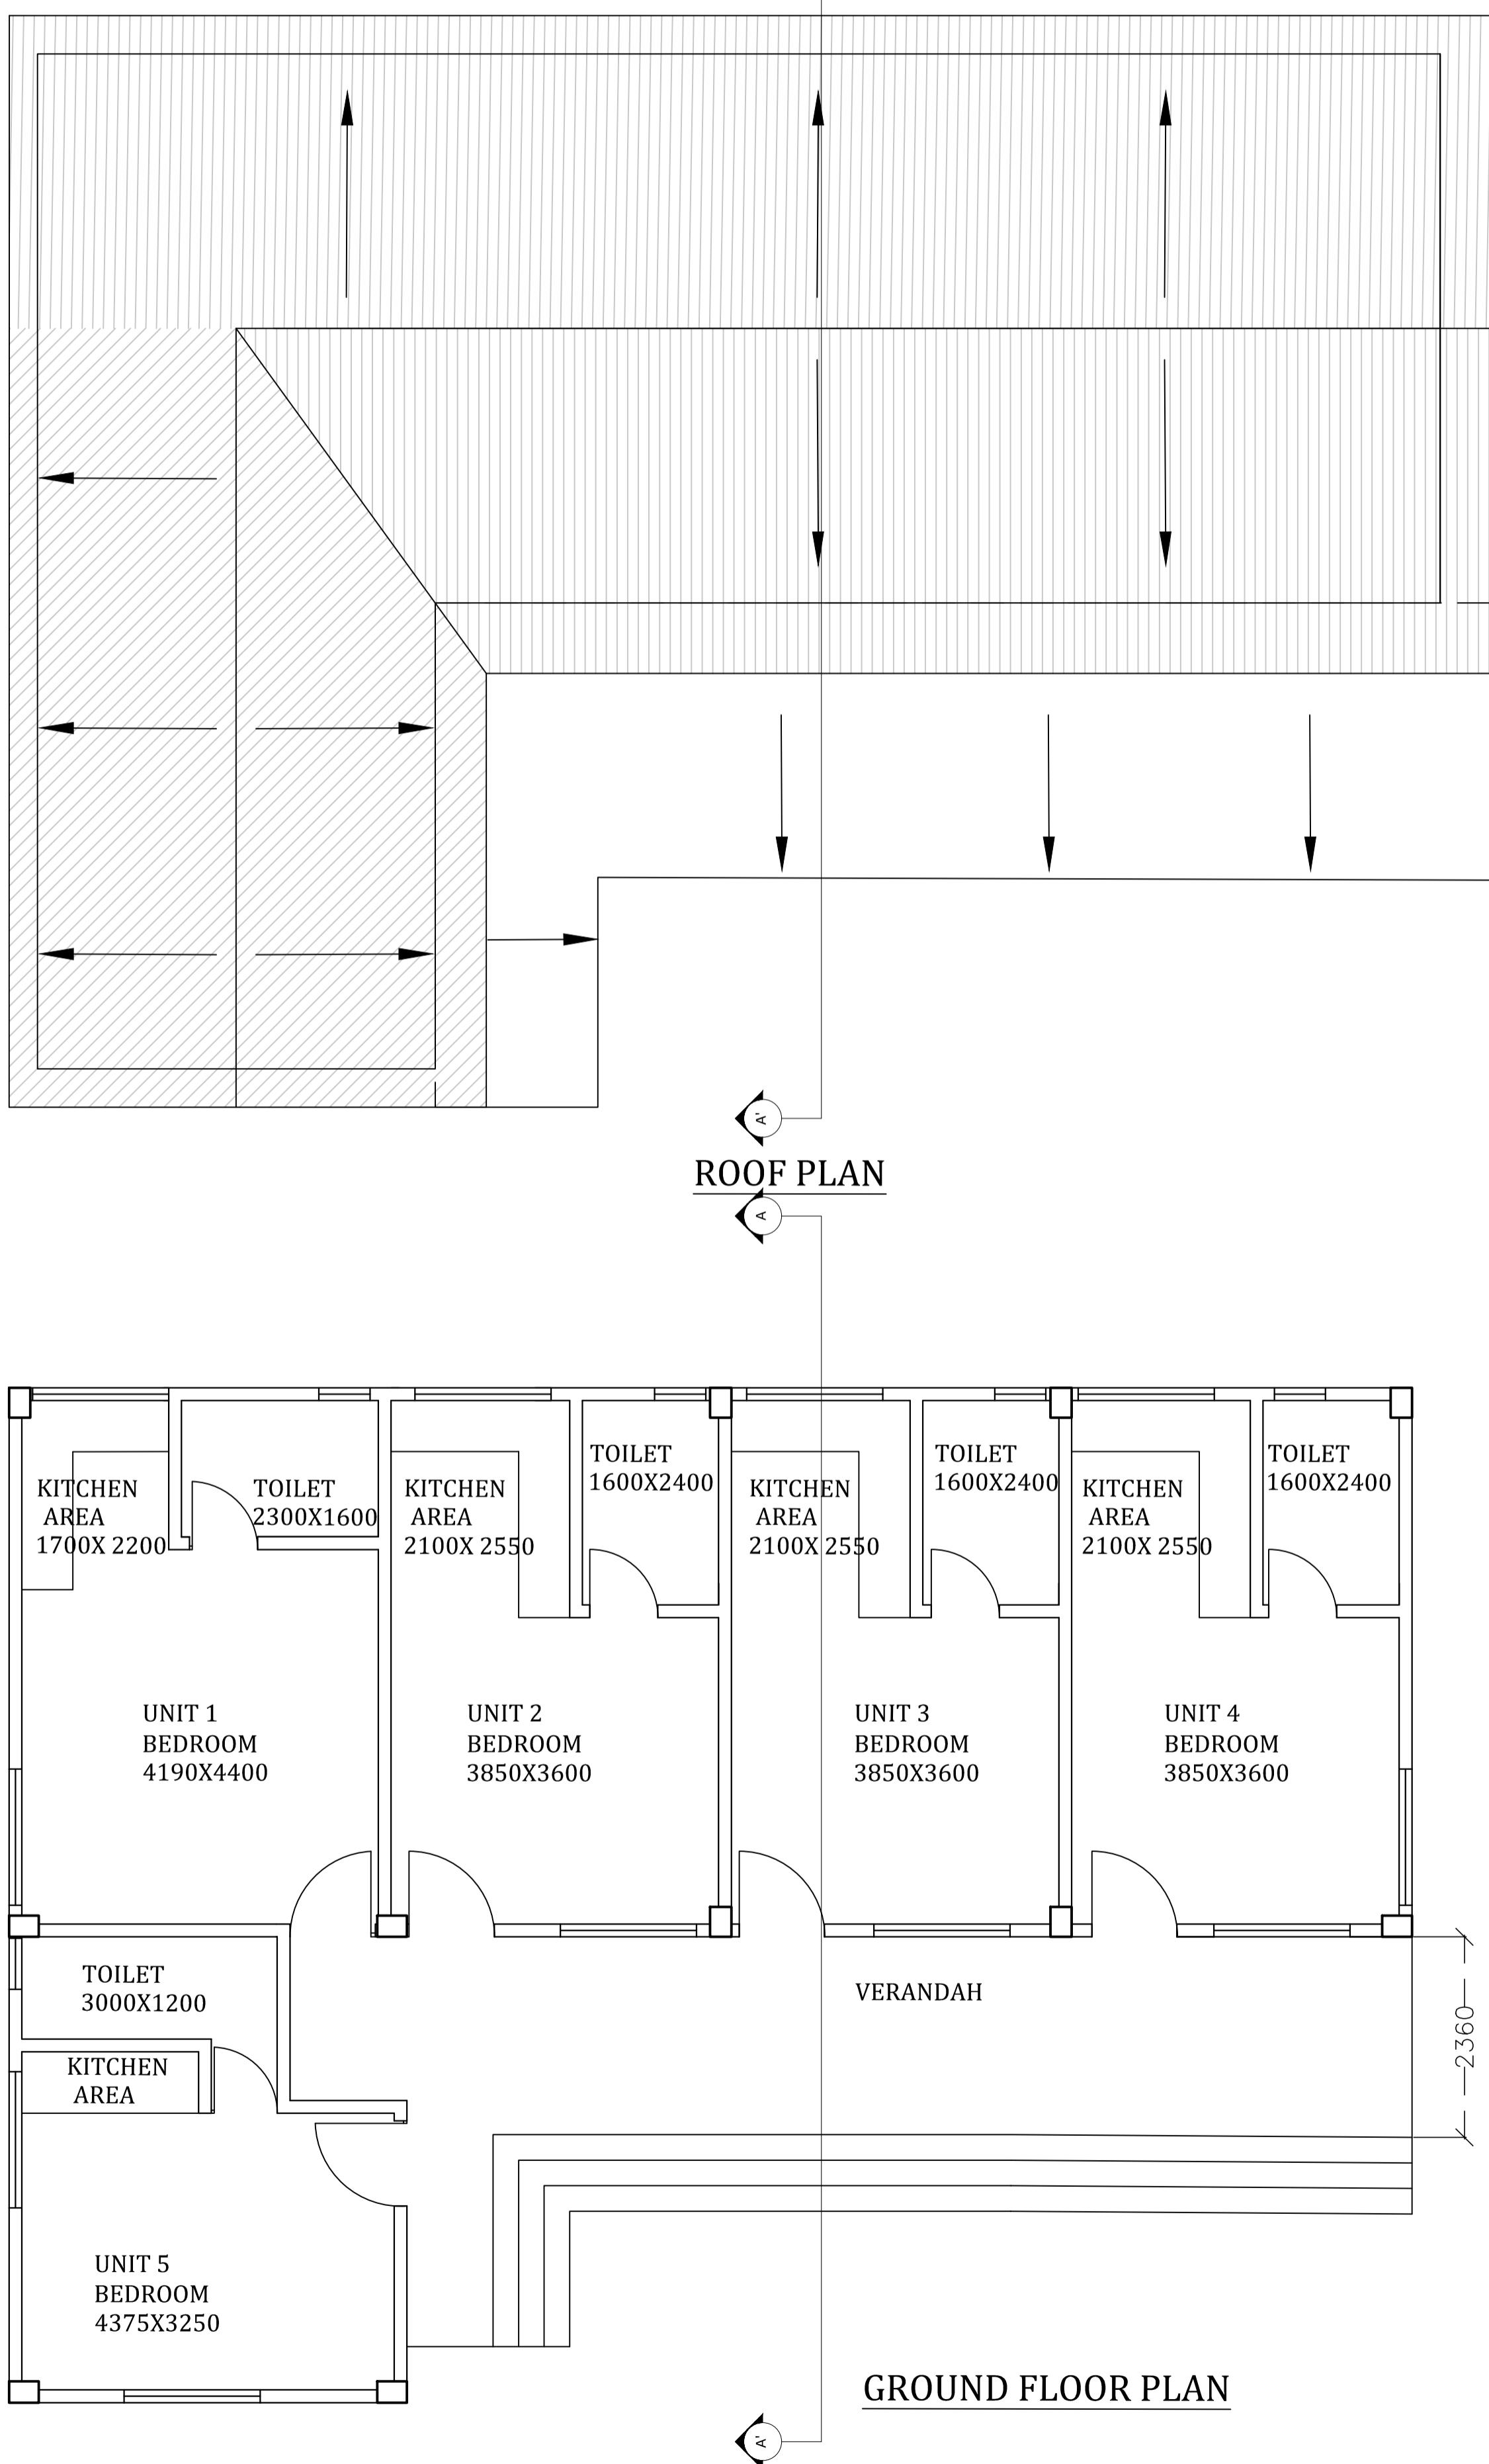

CONSULTANT:

CLIENT
Assam Inland Water Transport
Development Society.

Architectural and engineering services for
setting-up of office of Assam Inland
Water Transport Regulatory Authority
(AIWTRA) & Office of Assam Inland Water
Company Ltd. (AIWCL) at directorate of
IWT'S existing office building premises at
Ulubari, Guwahati (Assam).

GENERAL NOTES:

- 1. ALL DIMENSIONS ARE IN MILLIMETERS AND LEVELS IN METERS.**
- 2. THIS DRAWING IS NOT TO BE SCALED, FOLLOW WRITTEN DIMENSIONS.**
- 3. ANY DISCREPANCY SHALL FIRST BE CLARIFIED WITH THE CONSULTANT/ARCHITECT BEFORE PROCEEDING ANY FURTHER.**

PROJECT

Assam Inland Water Transport Development Project.

DRAWING TITLE

PROPOSED GROUND FLOOR


DISCIPLINE: RENOVATION


STATUS	DPR
--------	-----


FILE NAME:

DESIGNED: dhruv	DRAWN: samrat	
APPROVED: concerned	CHECKED: dhruv	
DATE: 30/08/23	SCALE 1:30	
GOV. 22/02	A-01	R-00


A1 DRAWINGS

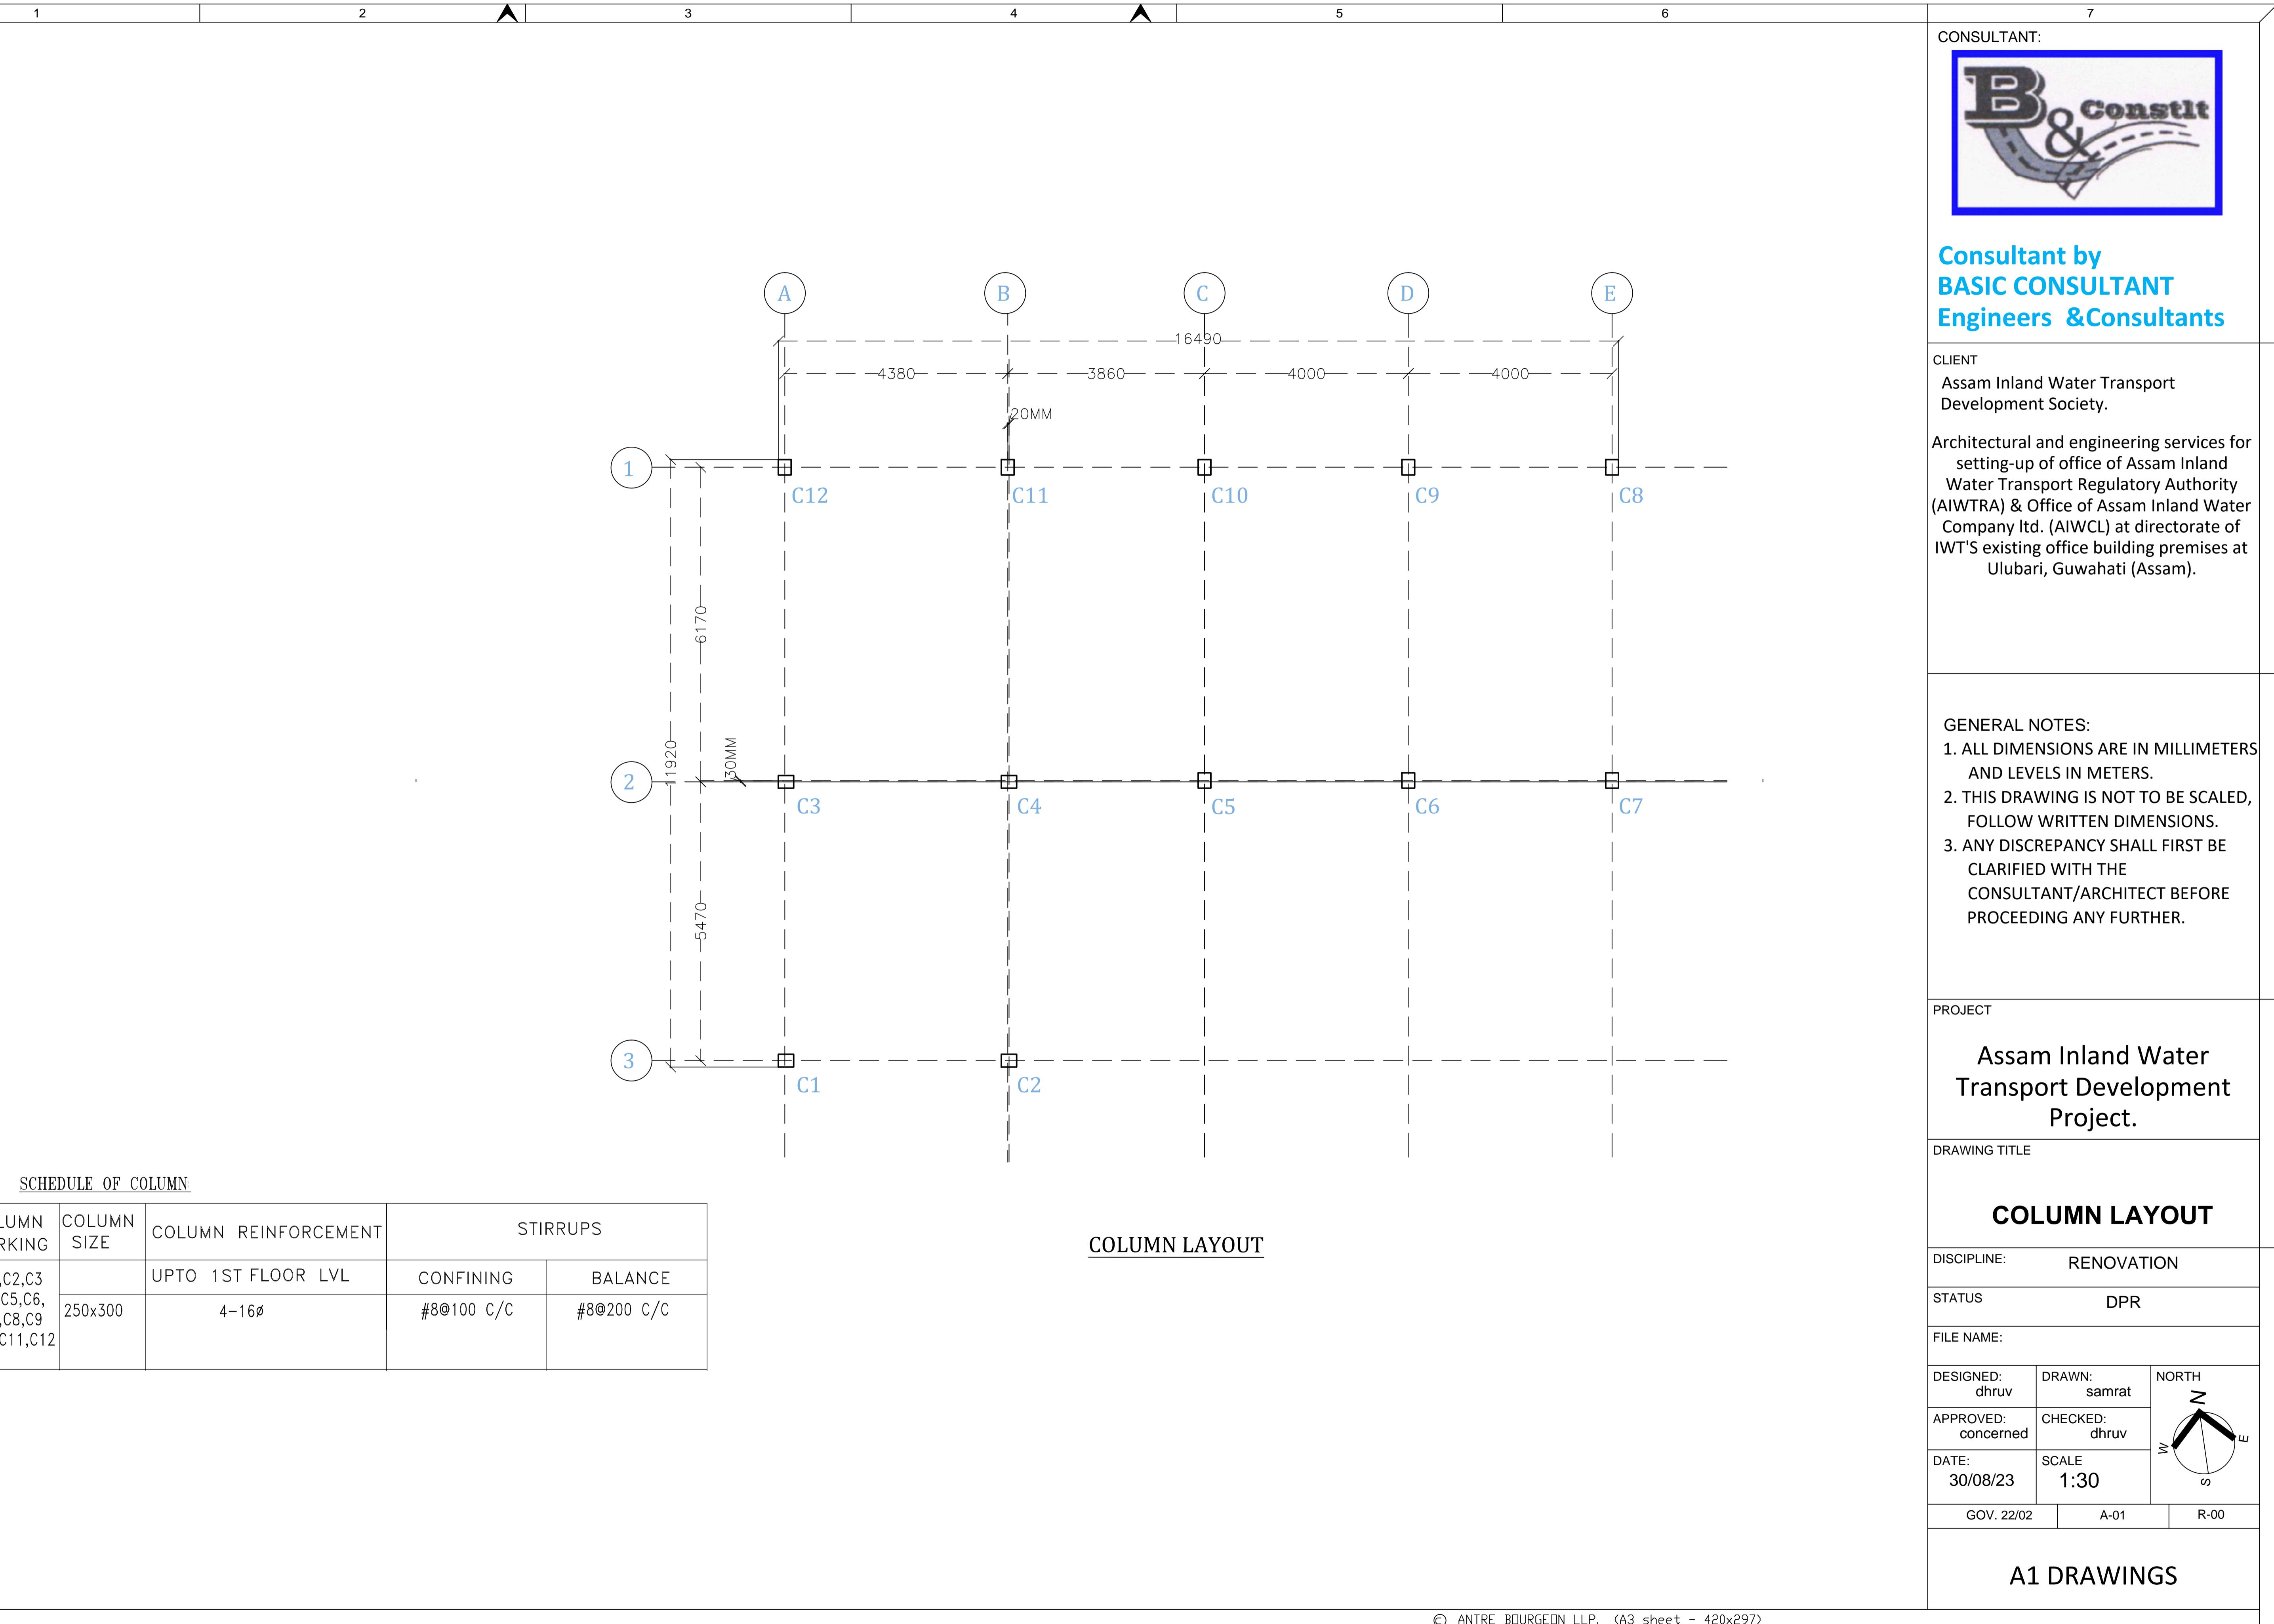

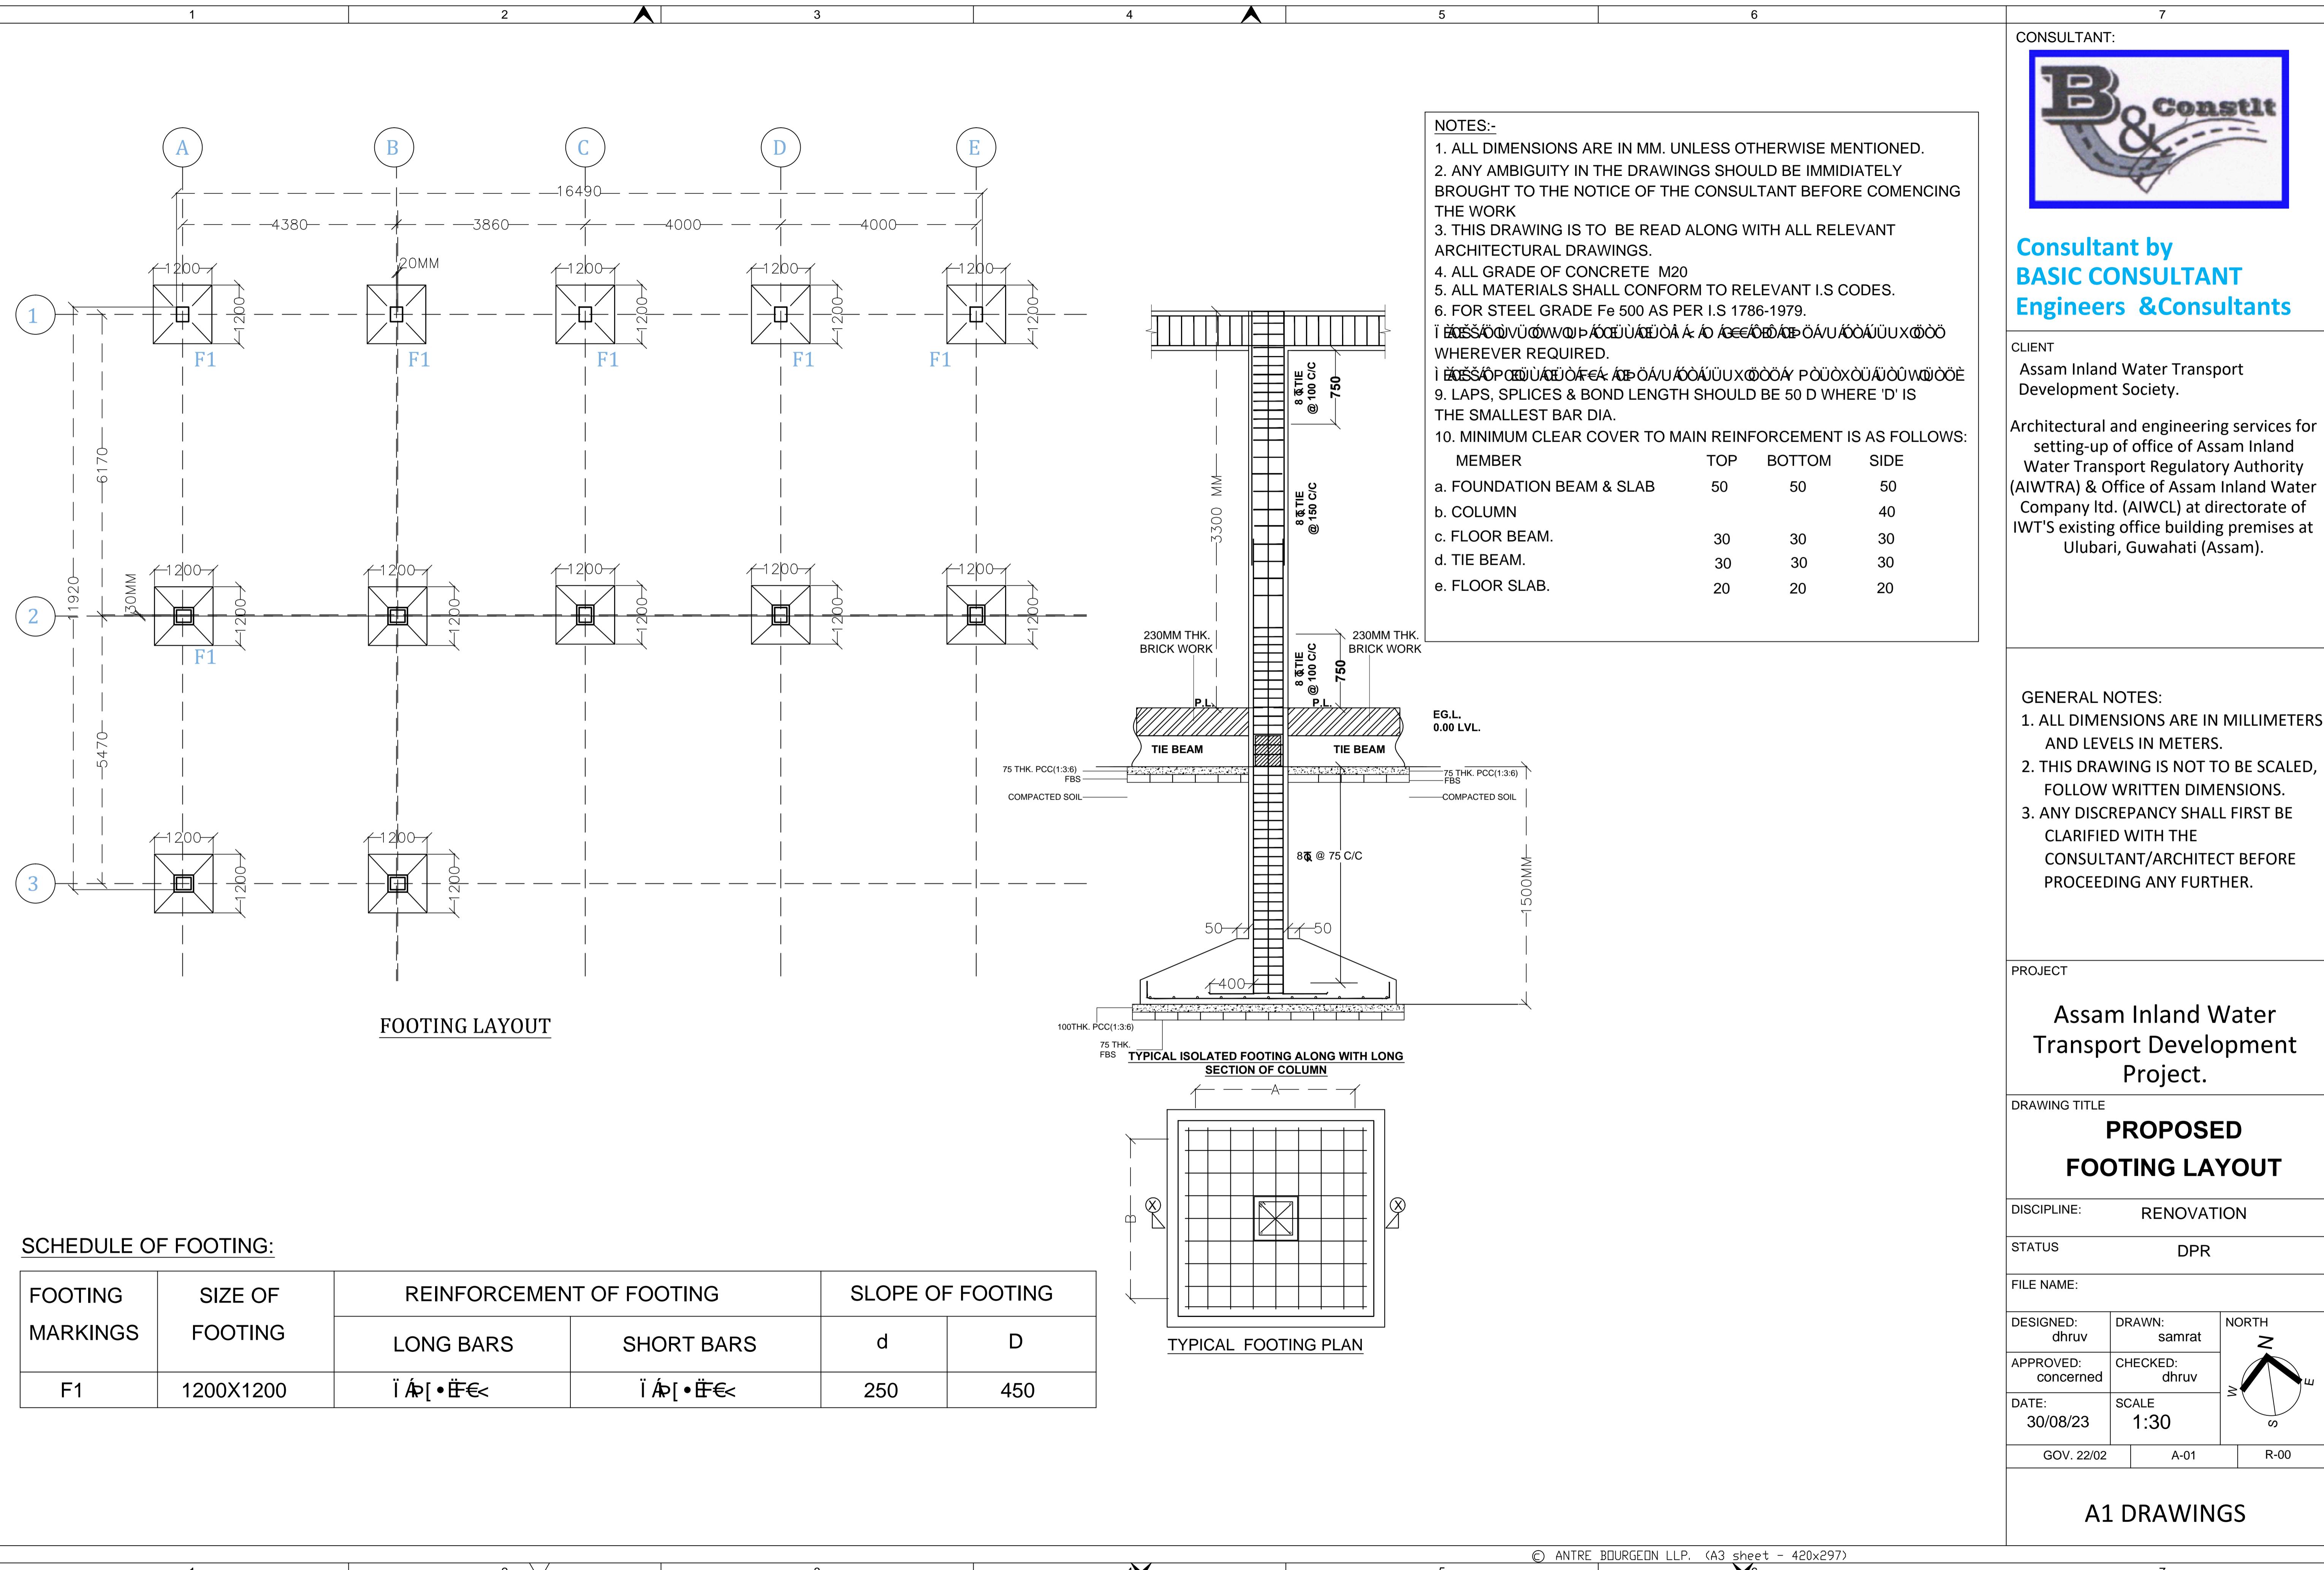

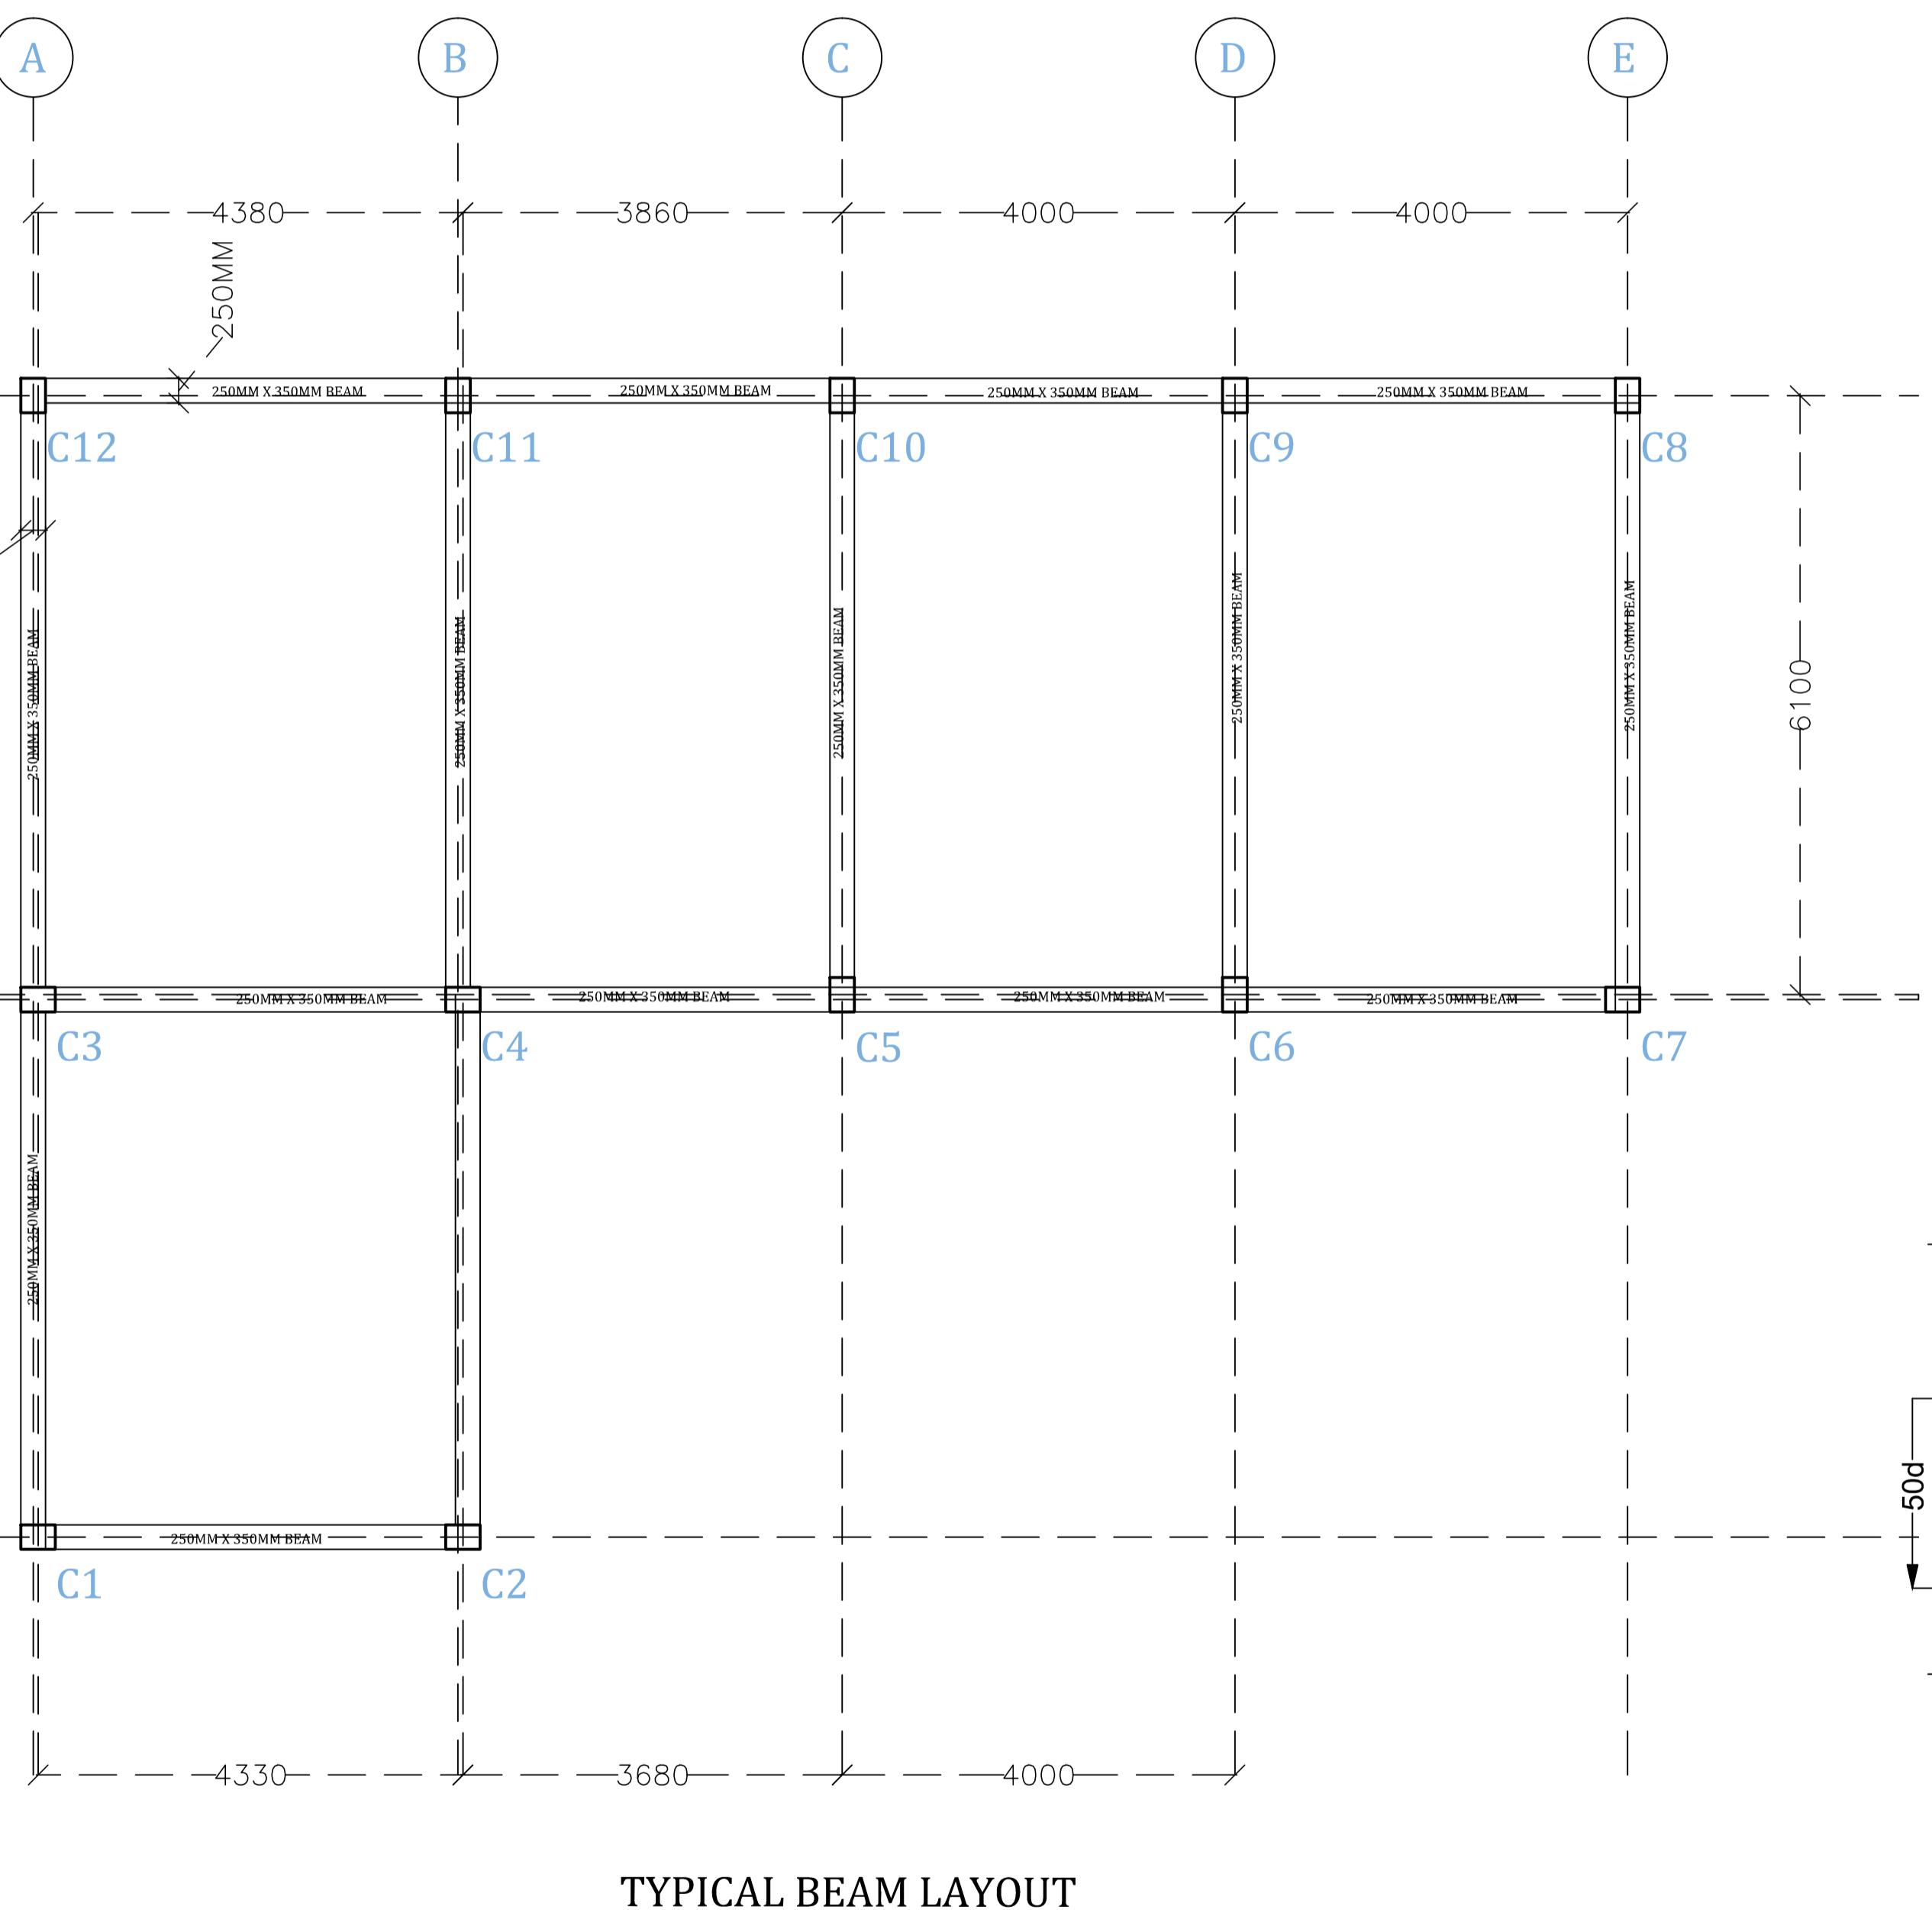


TYPICAL BEAM LAYOUT

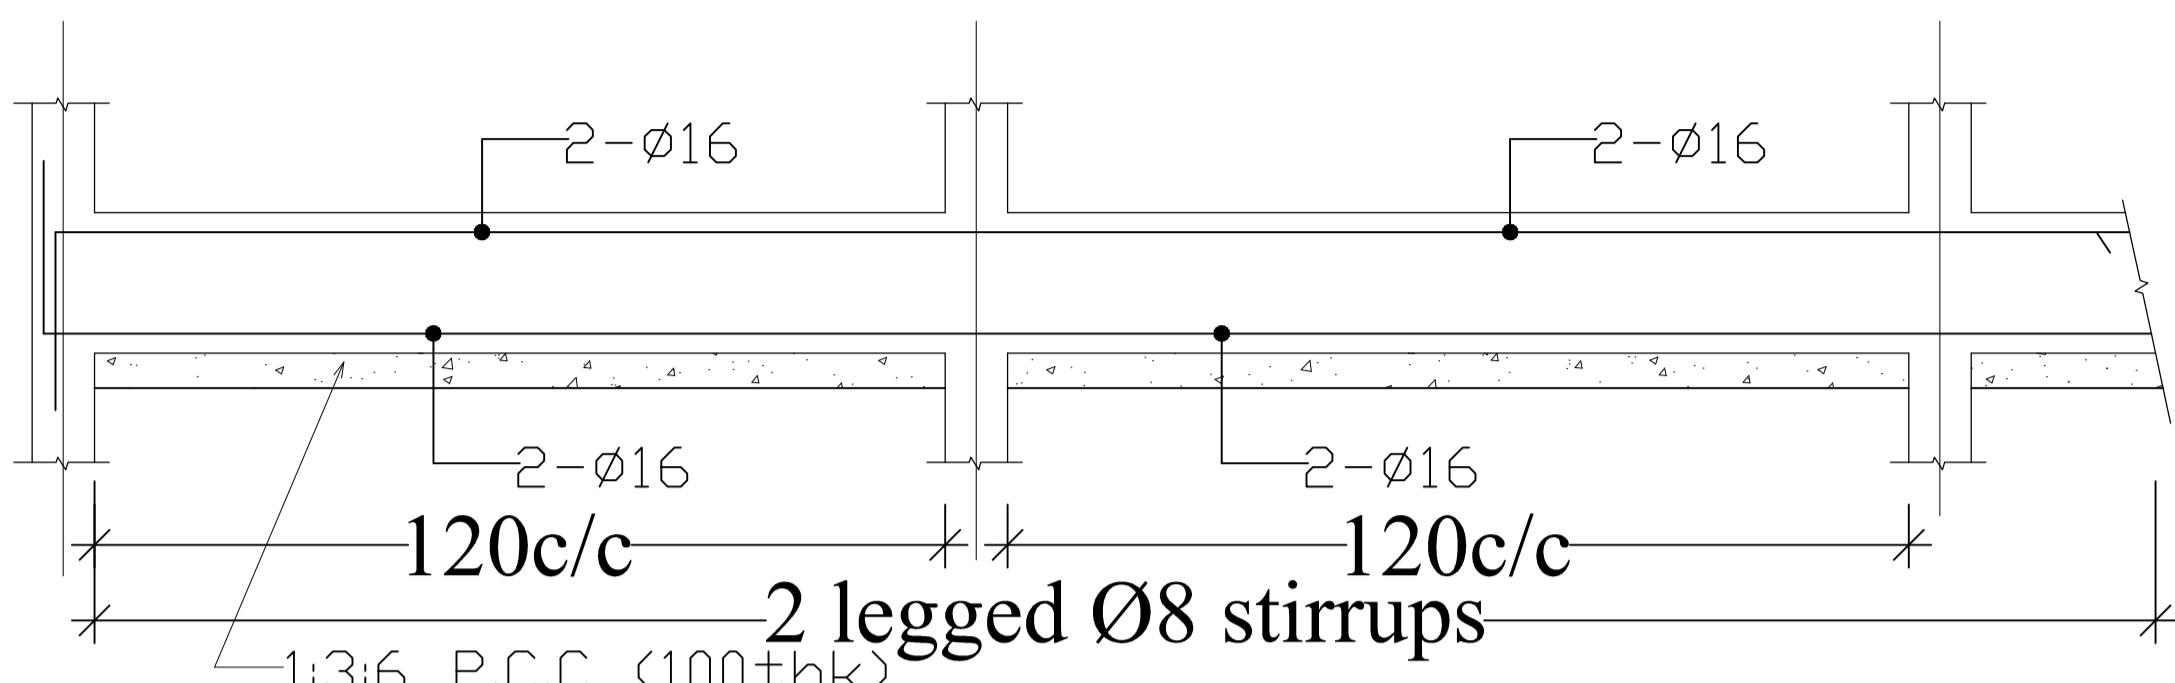


DETAILS OF TIE BEAM (FOR CONTINUOUS)

SIZE=250X300

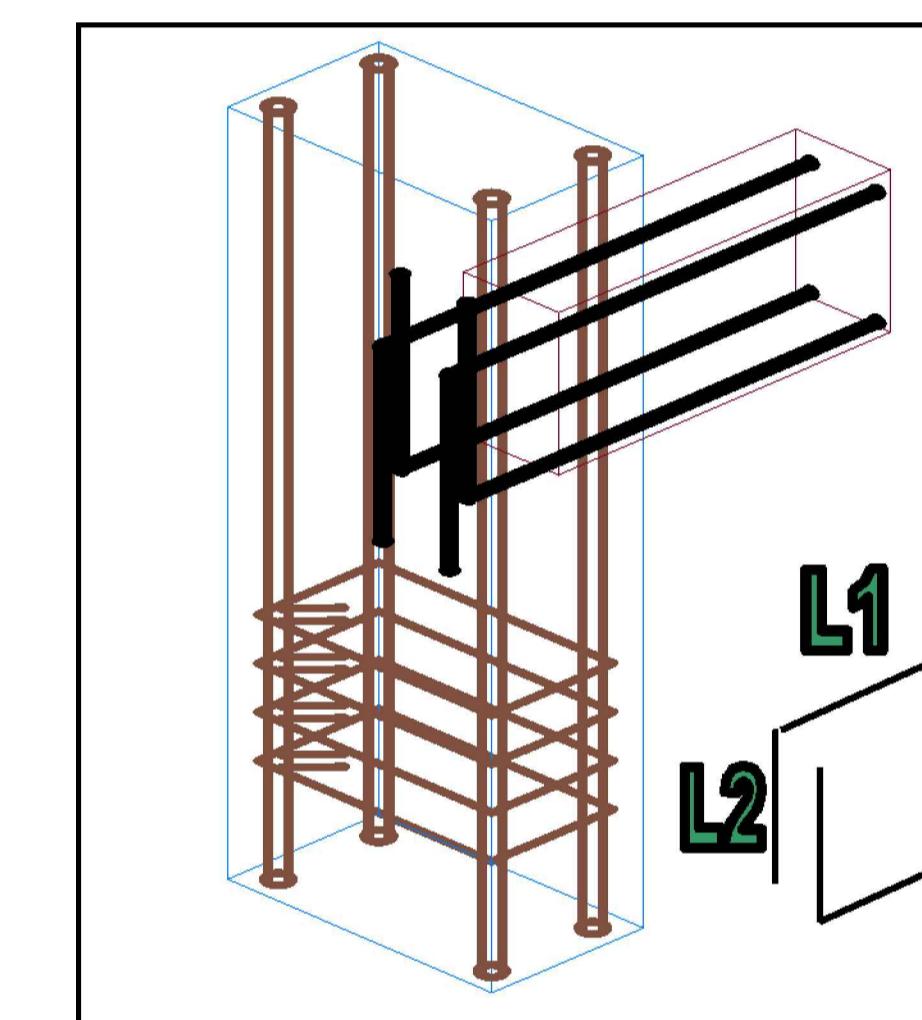

TYPICAL DETAIL FOR LAP SPLICE IN BEAM AND COL.

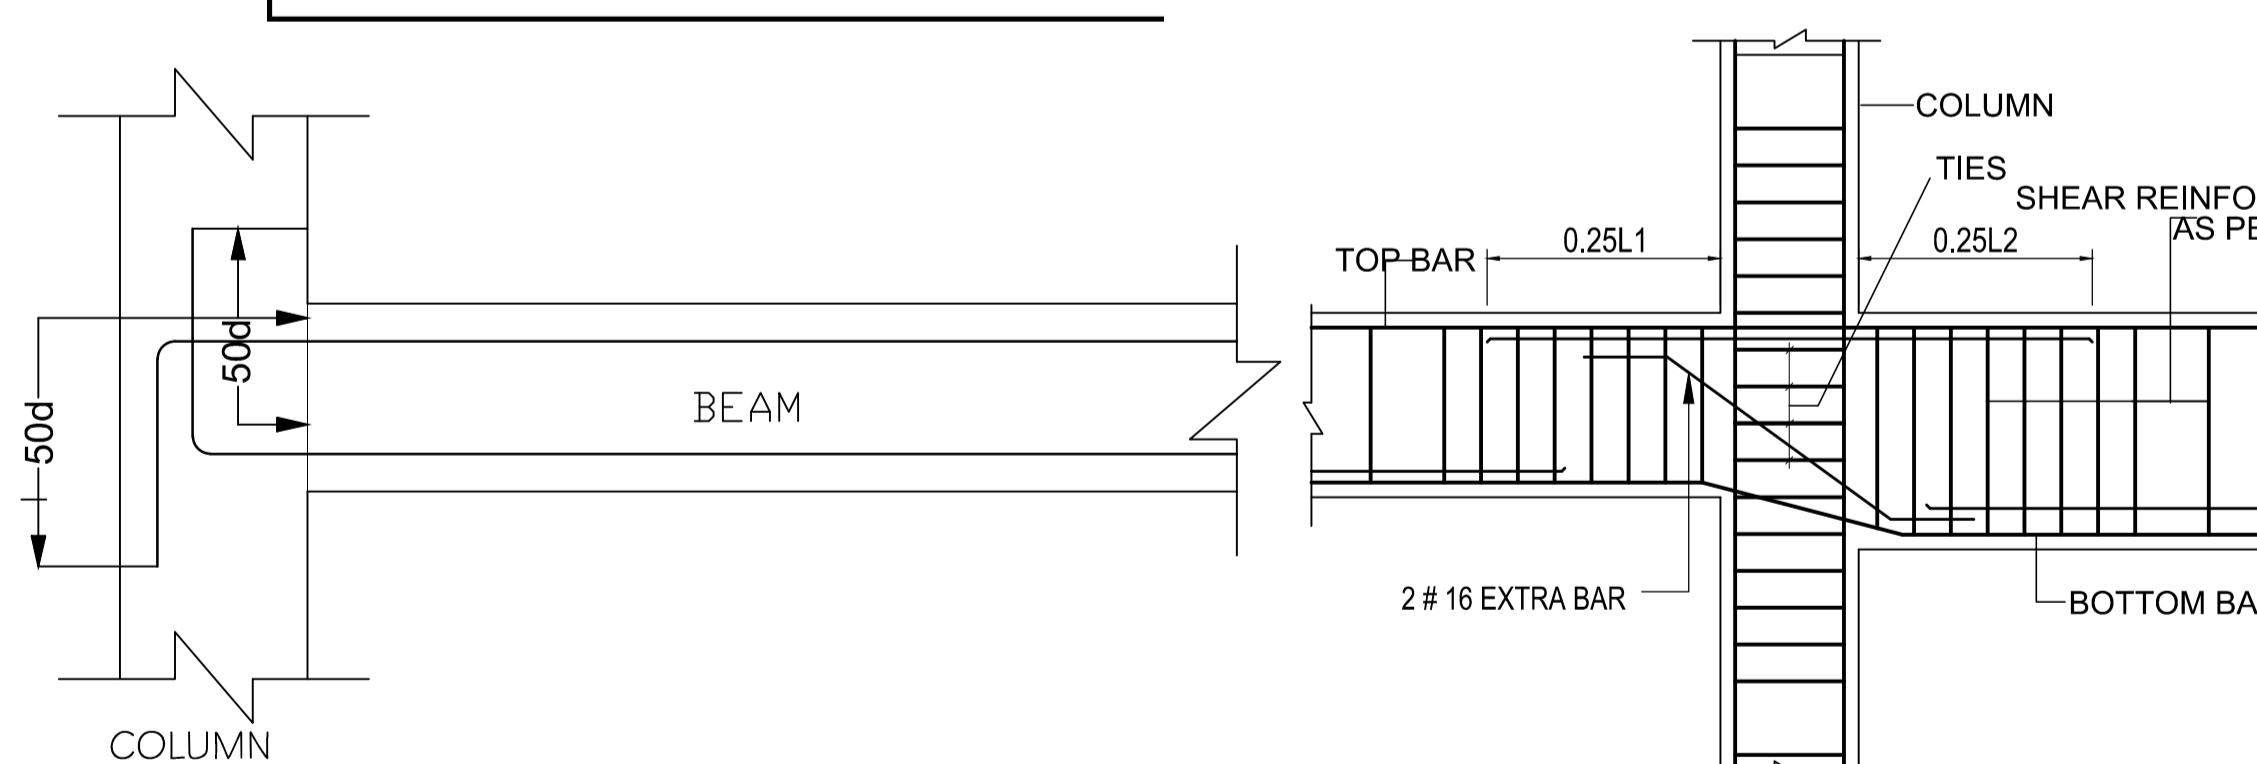

BAR BENDING DETAILS OF END COLUMN

(FOR MAIN AS WELL AS EXTRA BARS)

The logo for B&Constl is enclosed in a blue rectangular border. It features a large, bold, black 'B' on the left, followed by a stylized '&' symbol. To the right of the '&' is the word 'Constl' in a bold, black, sans-serif font. Below the 'B' and '&' is a blue road graphic that curves from the bottom left towards the center. The road has a dashed line on the right side and a solid line on the left side. The entire logo is set against a white background.

Consultant by **BASIC CONSULTANT** Engineers & Consultants

CLIENT

Assam Inland Water Transport Development Society.

Architectural and engineering services for setting-up of office of Assam Inland Water Transport Regulatory Authority (AIWTRA) & Office of Assam Inland Water Company Ltd. (AIWCL) at directorate of IWT'S existing office building premises at Ulubari, Guwahati (Assam).

GENERAL NOTES:

1. ALL DIMENSIONS ARE IN MILLIMETERS AND LEVELS IN METERS.
2. THIS DRAWING IS NOT TO BE SCALED, FOLLOW WRITTEN DIMENSIONS.
3. ANY DISCREPANCY SHALL FIRST BE CLARIFIED WITH THE CONSULTANT/ARCHITECT BEFORE PROCEEDING ANY FURTHER.

PROJECT

Assam Inland Water Transport Development Project

DRAWING TITLE

TYPICAL BEAM LAYOUT


DISCIPLINE: RENOVATION


FILE NAME

DESIGNED: dhruv	DRAWN: samrat	
APPROVED: concerned	CHECKED: dhruv	
DATE: 30/08/23	SCALE 1:30	

A1 DRAWINGS

1	2	3	4	5	6	7
E		A		A		E
D						D
C						C
B						B
A						A
CONSULTANT:						
						
Consultant by BASIC CONSULTANT Engineers & Consultants						
CLIENT Assam Inland Water Transport Development Society.						
Architectural and engineering services for setting-up of office of Assam Inland Water Transport Regulatory Authority (AIWTRA) & Office of Assam Inland Water Company Ltd. (AIWCL) at directorate of IWT'S existing office building premises at Ulubari, Guwahati (Assam).						
<h1>EXISTING PLAN</h1> <p>GENERAL NOTES:</p> <ol style="list-style-type: none"> 1. ALL DIMENSIONS ARE IN MILLIMETERS AND LEVELS IN METERS. 2. THIS DRAWING IS NOT TO BE SCALED, FOLLOW WRITTEN DIMENSIONS. 3. ANY DISCREPANCY SHALL FIRST BE CLARIFIED WITH THE CONSULTANT/ARCHITECT BEFORE PROCEEDING ANY FURTHER. 						
<p>PROJECT Assam Inland Water Transport Development Project.</p> <p>DRAWING TITLE 2ND FLOOR EXISTING PLAN</p> <p>DISCIPLINE: RENOVATION</p> <p>STATUS DPR</p> <p>FILE NAME:</p> <p>DESIGNED: dhruv DRAWN: samrat NORTH</p> <p>APPROVED: concerned CHECKED: dhruv</p> <p>DATE: 30/08/23 SCALE 1:15</p> <p>GOV. 22/02 A-01 R-00</p>						
A1 DRAWINGS						
1	2	3	4	5	6	7
E		A		A		E
D						D
C						C
B						B
A						A

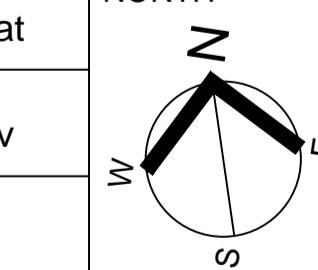1	2	3	4	5	6	7
E		A		A		E
D						D
C						C
B						B
A						A
CONSULTANT:						
						
Consultant by BASIC CONSULTANT Engineers & Consultants						
CLIENT Assam Inland Water Transport Development Society.						
Architectural and engineering services for setting-up of office of Assam Inland Water Transport Regulatory Authority (AIWTRA) & Office of Assam Inland Water Company Ltd. (AIWCL) at directorate of IWT'S existing office building premises at Ulubari, Guwahati (Assam).						
GENERAL NOTES: 1. ALL DIMENSIONS ARE IN MILLIMETERS AND LEVELS IN METERS. 2. THIS DRAWING IS NOT TO BE SCALED, FOLLOW WRITTEN DIMENSIONS. 3. ANY DISCREPANCY SHALL FIRST BE CLARIFIED WITH THE CONSULTANT/ARCHITECT BEFORE PROCEEDING ANY FURTHER.						
PROJECT Assam Inland Water Transport Development Project.						
DRAWING TITLE 2ND FLOOR DEMOLISHING PLAN						
DISCIPLINE: RENOVATION						
STATUS DPR						
FILE NAME:						
DESIGNED: dhruv		DRAWN: samrat		NORTH		
APPROVED: concerned		CHECKED: dhruv				
DATE: 30/08/23		SCALE 1:15				
GOV. 22/02		A-01		R-00		
A1 DRAWINGS						
1	2	3	4	5	6	7
V	V	V	V	V	V	

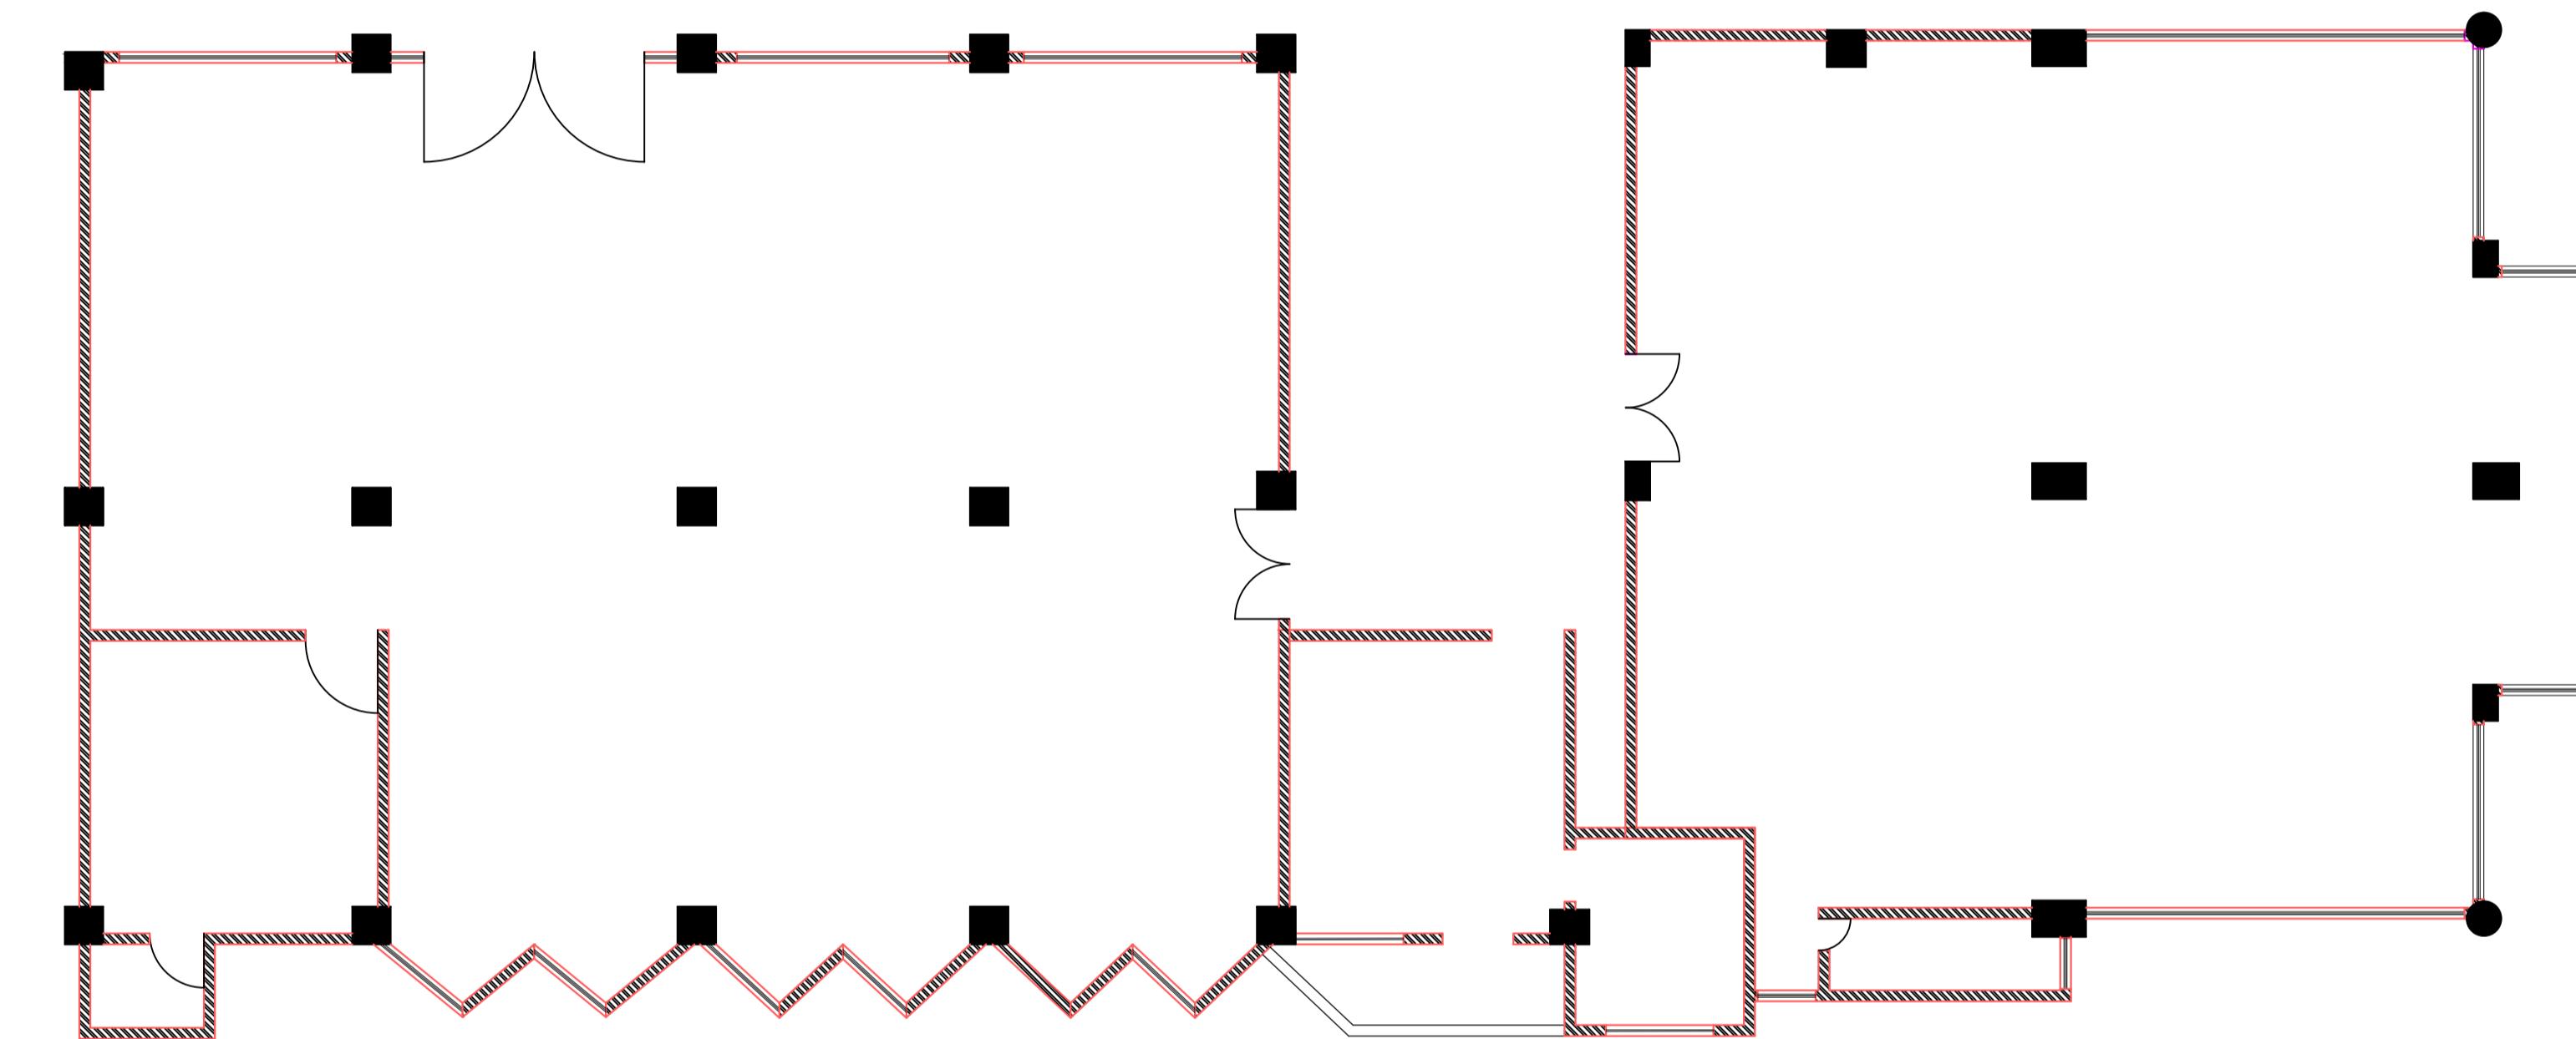

LEGEND :		
	DEMOLISHING WALLS	
	EXISTING WALLS	
	RCC COLUMN	

1 2 3 4 5 6 7

PROPOSED PLAN

CONSULTANT:



Consultant by
BASIC CONSULTANT
Engineers & Consultants

CLIENT

Assam Inland Water Transport
Development Society.

Architectural and engineering services for
setting-up of office of Assam Inland Water
Transport Regulatory Authority (AIWTRA)
& Office of Assam Inland Water Company
Ltd. (AIWCL) at directorate of IWT'S
existing office building premises at Ulubari,
Guwahati (Assam).



GENERAL NOTES:

1. ALL DIMENSIONS ARE IN MILLIMETERS
AND LEVELS IN METERS.
2. THIS DRAWING IS NOT TO BE SCALED,
FOLLOW WRITTEN DIMENSIONS.
3. ANY DISCREPANCY SHALL FIRST BE
CLARIFIED WITH THE
CONSULTANT/ARCHITECT BEFORE
PROCEEDING ANY FURTHER.

PROJECT

Assam Inland Water
Transport Development
Project.

DRAWING TITLE
**2ND FLOOR
PROPOSED PLAN**

DISCIPLINE: RENOVATION

STATUS DPR


FILE NAME:

DESIGNED:	DRAWN:	NORTH
dhruv	samrat	
APPROVED:	CHECKED:	
concerned	dhruv	

DATE: 30/08/23 SCALE: 1:15


GOV. 22/02 A-01 R-00


A1 DRAWINGS

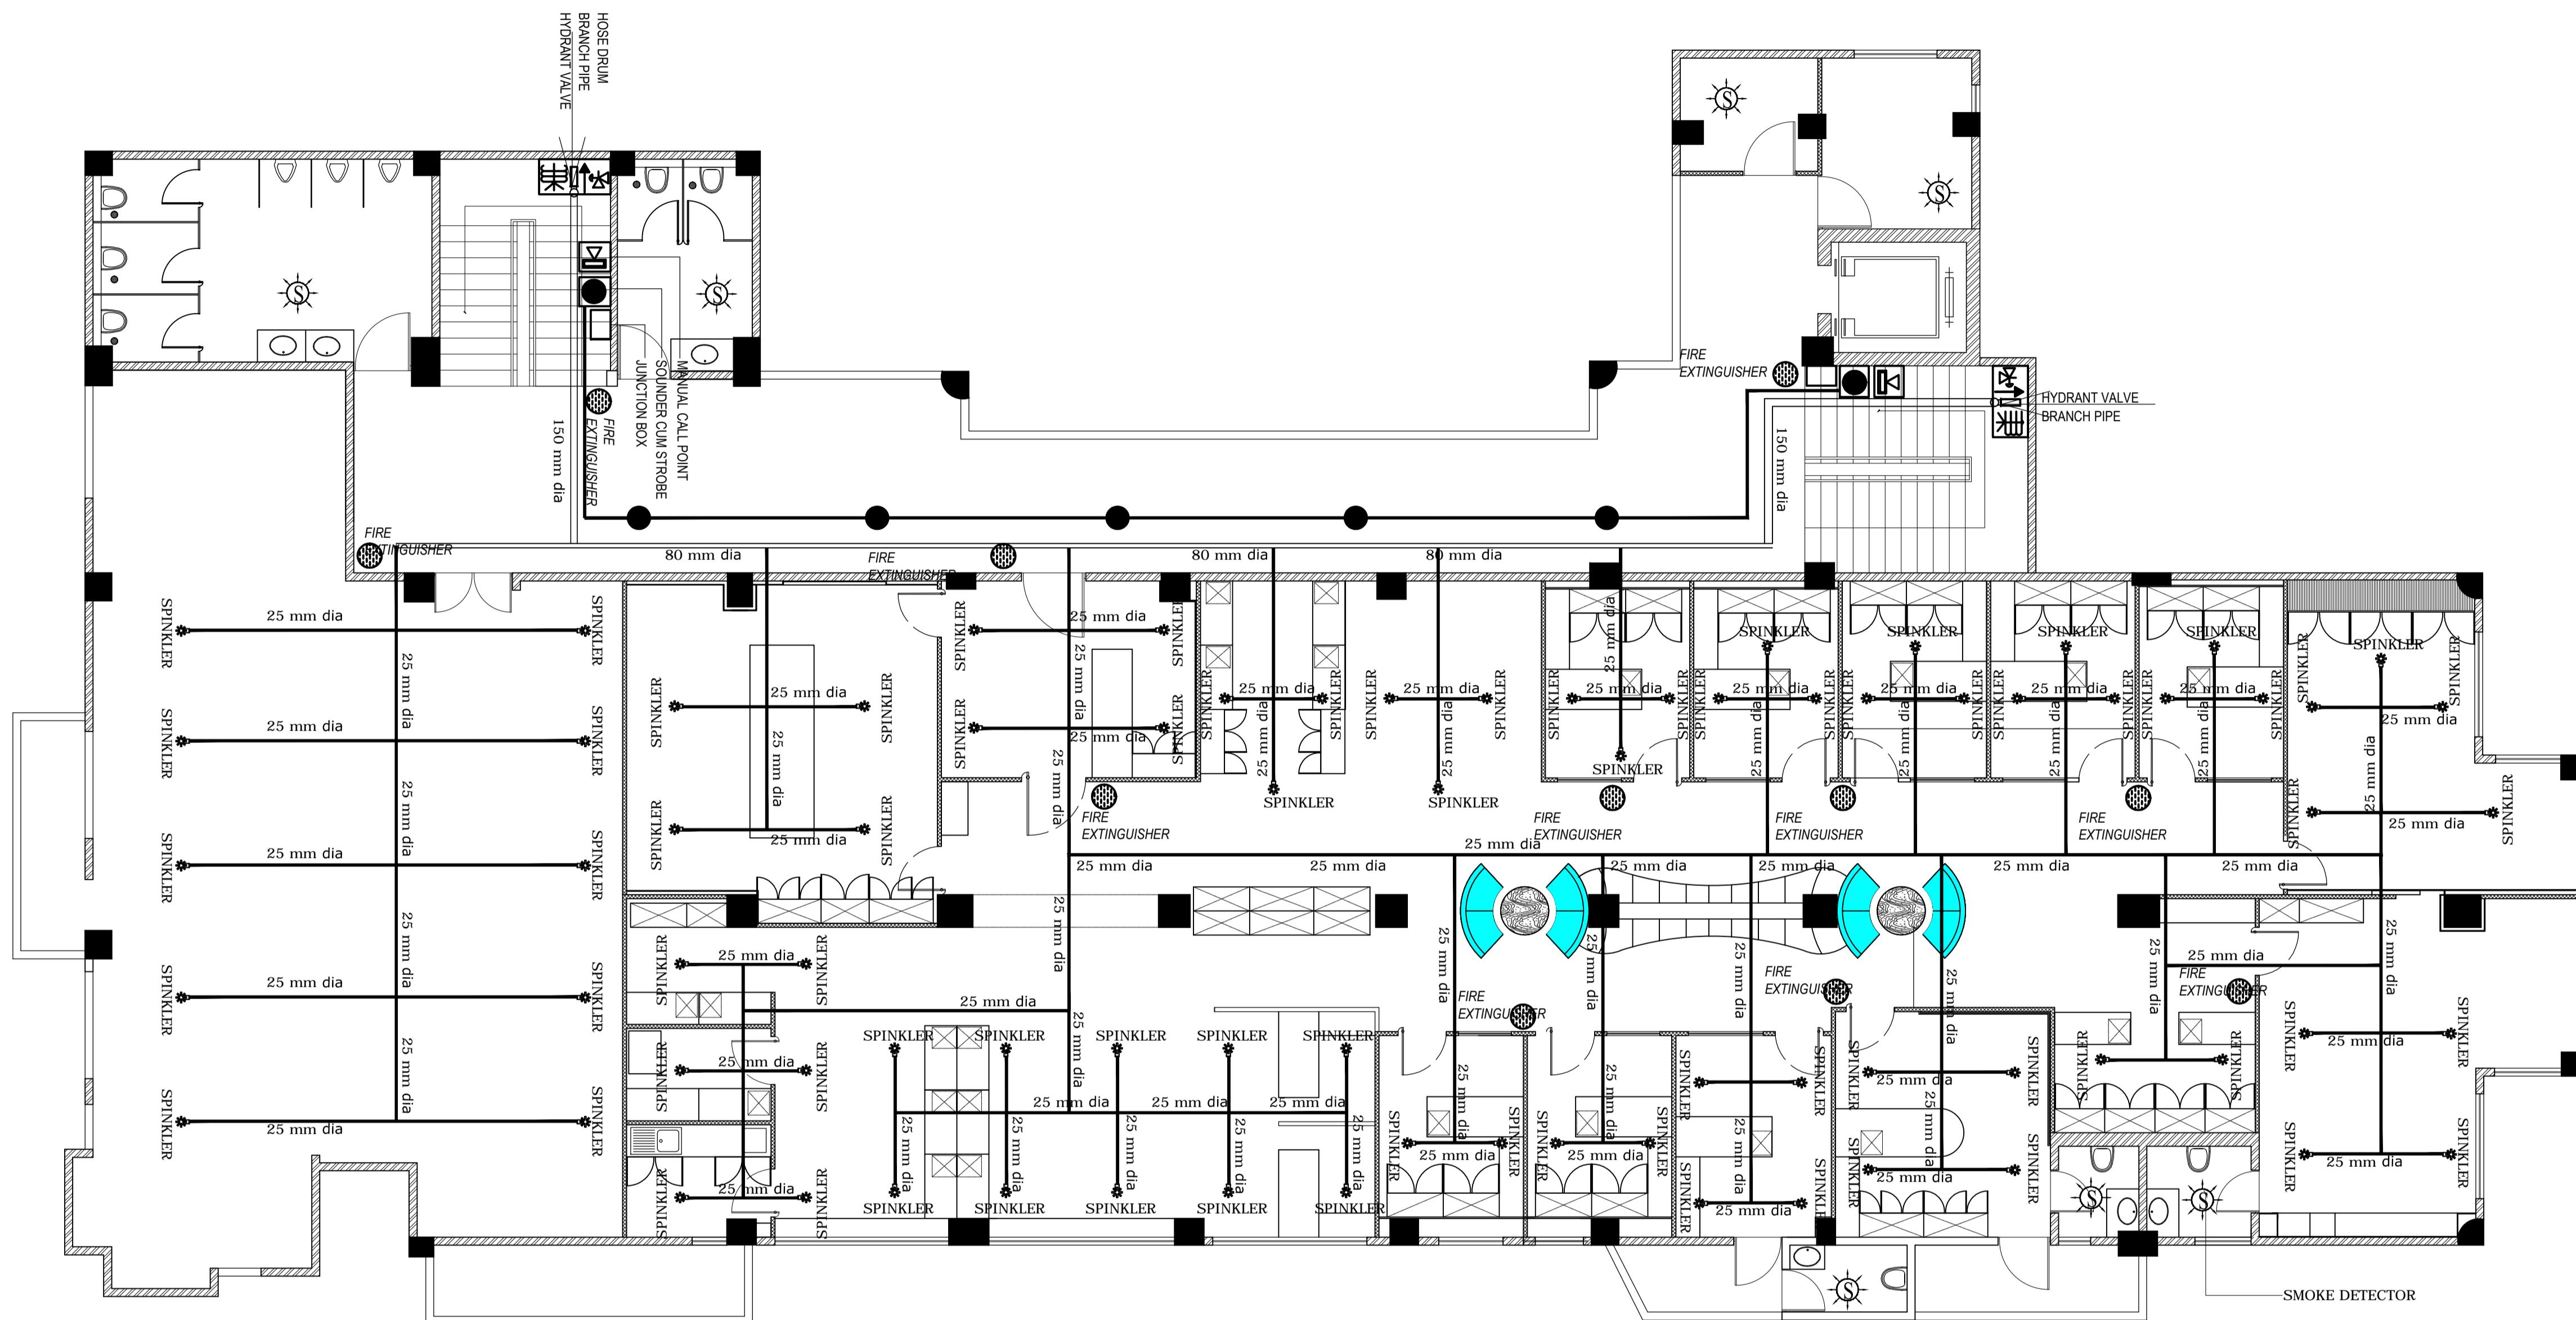


SECOND FLOOR

FIRE FIGTHING

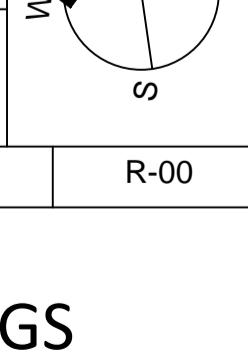
CONSULTANT:		
		
<p>Consultant by BASIC CONSULTANT Engineers & Consultants</p>		
CLIENT	<p>Assam Inland Water Transport Development Society.</p> <p>Architectural and engineering services for setting-up of office of Assam Inland Water Transport Regulatory Authority (AIWTRA) & Office of Assam Inland Water Company Ltd. (AIWCL) at directorate of IWT'S existing office building premises at Ulubari, Guwahati (Assam).</p>	
<p>GENERAL NOTES:</p> <ol style="list-style-type: none"> 1. ALL DIMENSIONS ARE IN MILLIMETER AND LEVELS IN METERS. 2. THIS DRAWING IS NOT TO BE SCALED, FOLLOW WRITTEN DIMENSIONS. 3. ANY DISCREPANCY SHALL FIRST BE CLARIFIED WITH THE CONSULTANT/ARCHITECT BEFORE PROCEEDING ANY FURTHER. 		
PROJECT	<p>Assam Inland Water Transport Development Project.</p>	
DRAWING TITLE	<p>SECOND FLOOR FIRE FIGTHING</p>	
DISCIPLINE:	RENOVATION	
STATUS	DPR	
FILE NAME:		
DESIGNED: dhruv	DRAWN: samrat	<p>NORTH</p> 
APPROVED: concerned	CHECKED: dhruv	
DATE: 30/08/23	SCALE 1:15	
GOV. 22/02	A-01	
R-00		
A1 DRAWINGS		

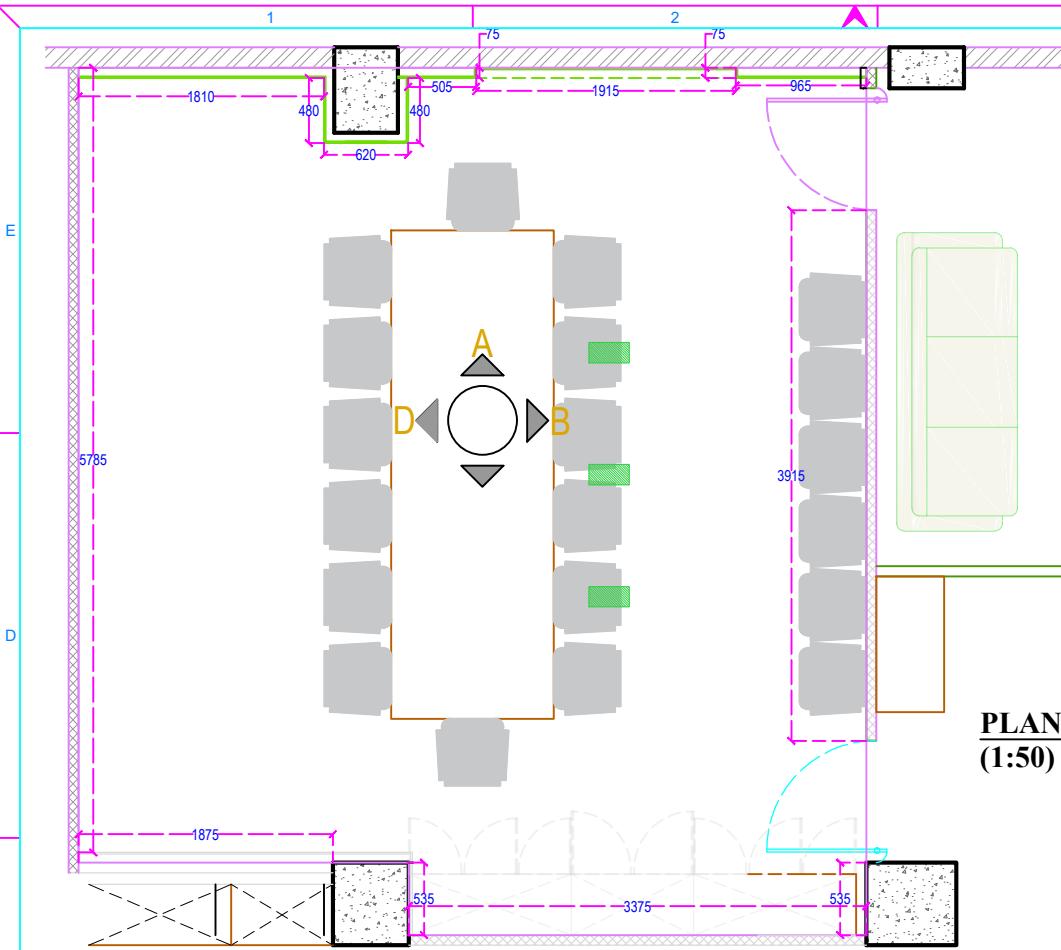


PLAN
(1:50)

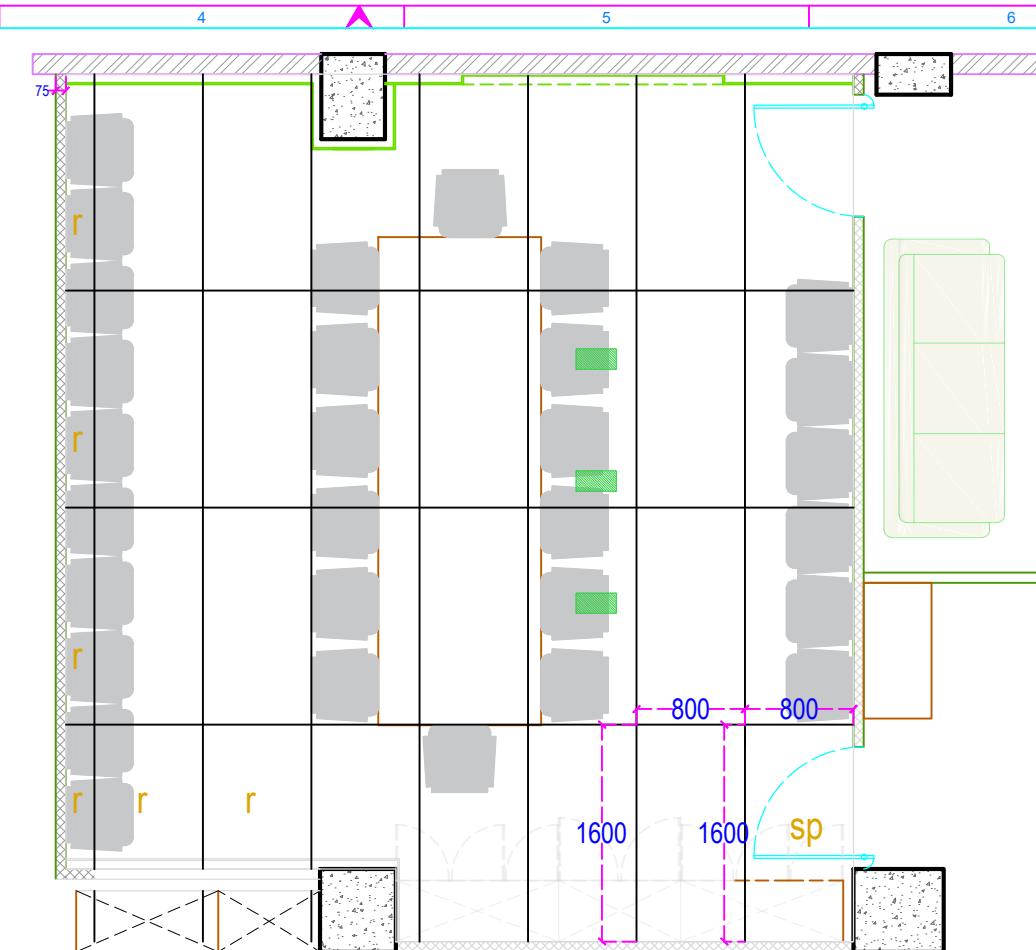

TILES LAYOUT PLAN(1:50)

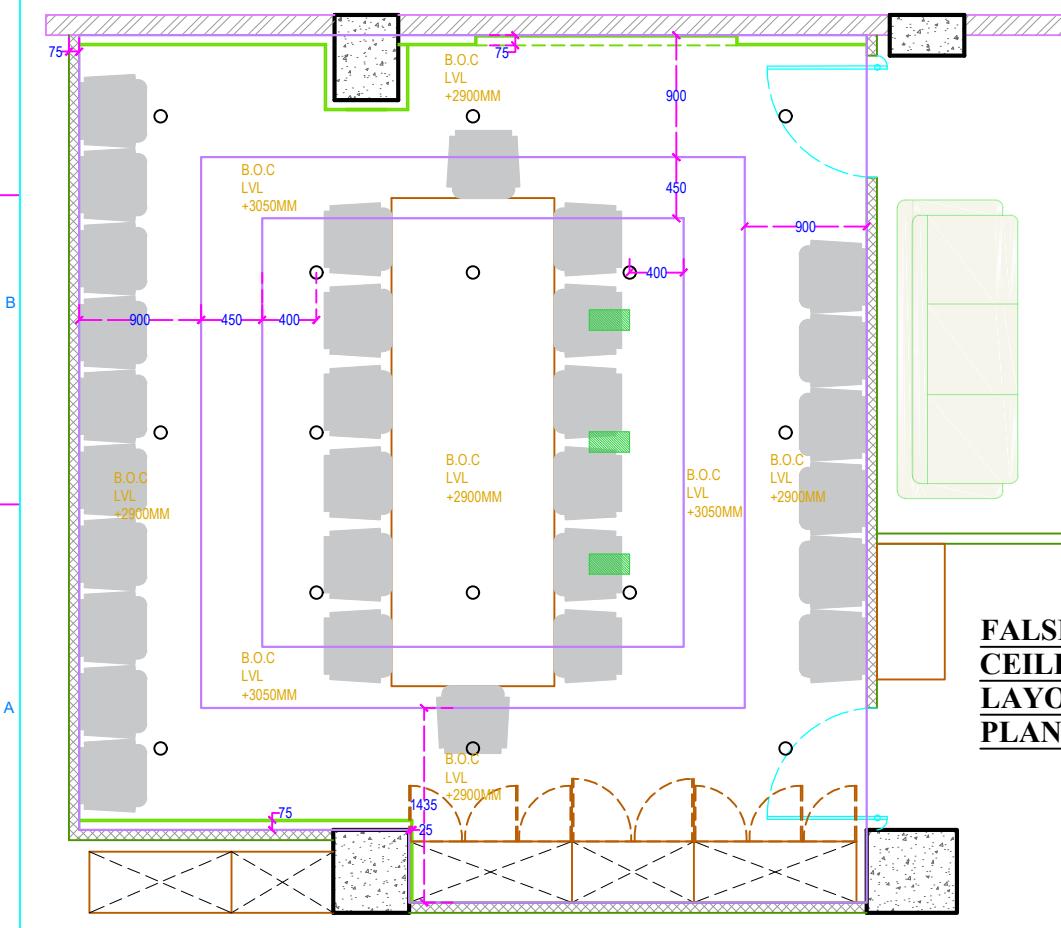

FALSE CEILING LAYOUT PLAN(1:50)

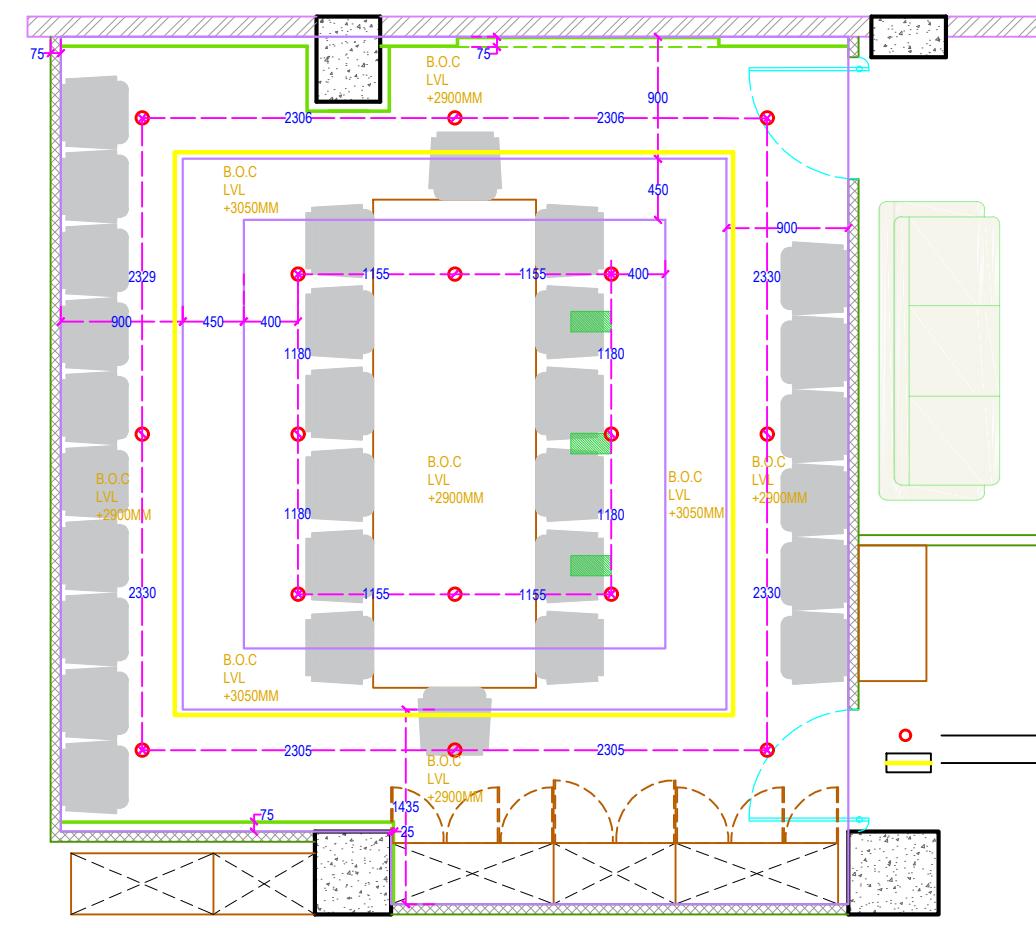

FALSE CEILING LIGHTING LAYOUT PLAN(1:50)

CONSULTANT:

Consultant by **BASIC CONSULTANT** Engineers & Consultants

CLIENT
Assam Inland Water Transport
Development Society.

Architectural and engineering services for setting-up of office of Assam Inland Water Transport Regulatory Authority (AIWTRA) & Office of Assam Inland Water Company Ltd. (AIWCL) at directorate of IWT'S existing office building premises at Ulubari, Guwahati (Assam).

GENERAL NOTES:

1. ALL DIMENSIONS ARE IN MILLIMETERS
AND LEVELS IN METERS.
2. THIS DRAWING IS NOT TO BE SCALED,
FOLLOW WRITTEN DIMENSIONS.
3. ANY DISCREPANCY SHALL FIRST BE
CLARIFIED WITH THE
CONSULTANT/ARCHITECT BEFORE
PROCEEDING ANY FURTHER.

PROJECT

Assam Inland Water Transport Development Project

DRAWING TITLE

CONFERENCE

PEANOS

SETTINGS

FILE NAME:

DESIGNED: DRA

APPROVED: CHE

DATE: SCA

04/09/23 1

GOV. 22/02



A3 DRAWINGS

1

2

3

4

5

6

7

CONSULTANT:



**Consultant by
BASIC CONSULTANT
Engineers & Consultants**

CLIENT

Assam Inland Water Transport
Development Society.

Architectural and engineering services
for setting-up of office of Assam Inland
Water Transport Regulatory Authority
(AIWTRA) & Office of Assam Inland
Water Company Ltd. (AIWCL) at
directorate of IWT'S existing office
building premises at Ulubari, Guwahati
(Assam).

GENERAL NOTES:

1. ALL DIMENSIONS ARE IN MILLIMETERS
AND LEVELS IN METERS.
2. THIS DRAWING IS NOT TO BE SCALED,
FOLLOW WRITTEN DIMENSIONS.
3. ANY DISCREPANCY SHALL FIRST BE
CLARIFIED WITH THE
CONSULTANT/ARCHITECT BEFORE
PROCEEDING ANY FURTHER.

PROJECT

**Assam Inland Water
Transport Development
Project.**

**DRAWING TITLE
CONFERENCE ROOM**

ELEVATION


DISCIPLINE: RENOVATION

STATUS: DPR

FILE NAME:

DESIGNED: dhruv	DRAWN: samrat	NORTH
APPROVED: concerned	CHECKED: dhruv	
DATE: 04/09/23	SCALE 1:50	
GOV. 22/02	A-01	R-00

A3 DRAWINGS

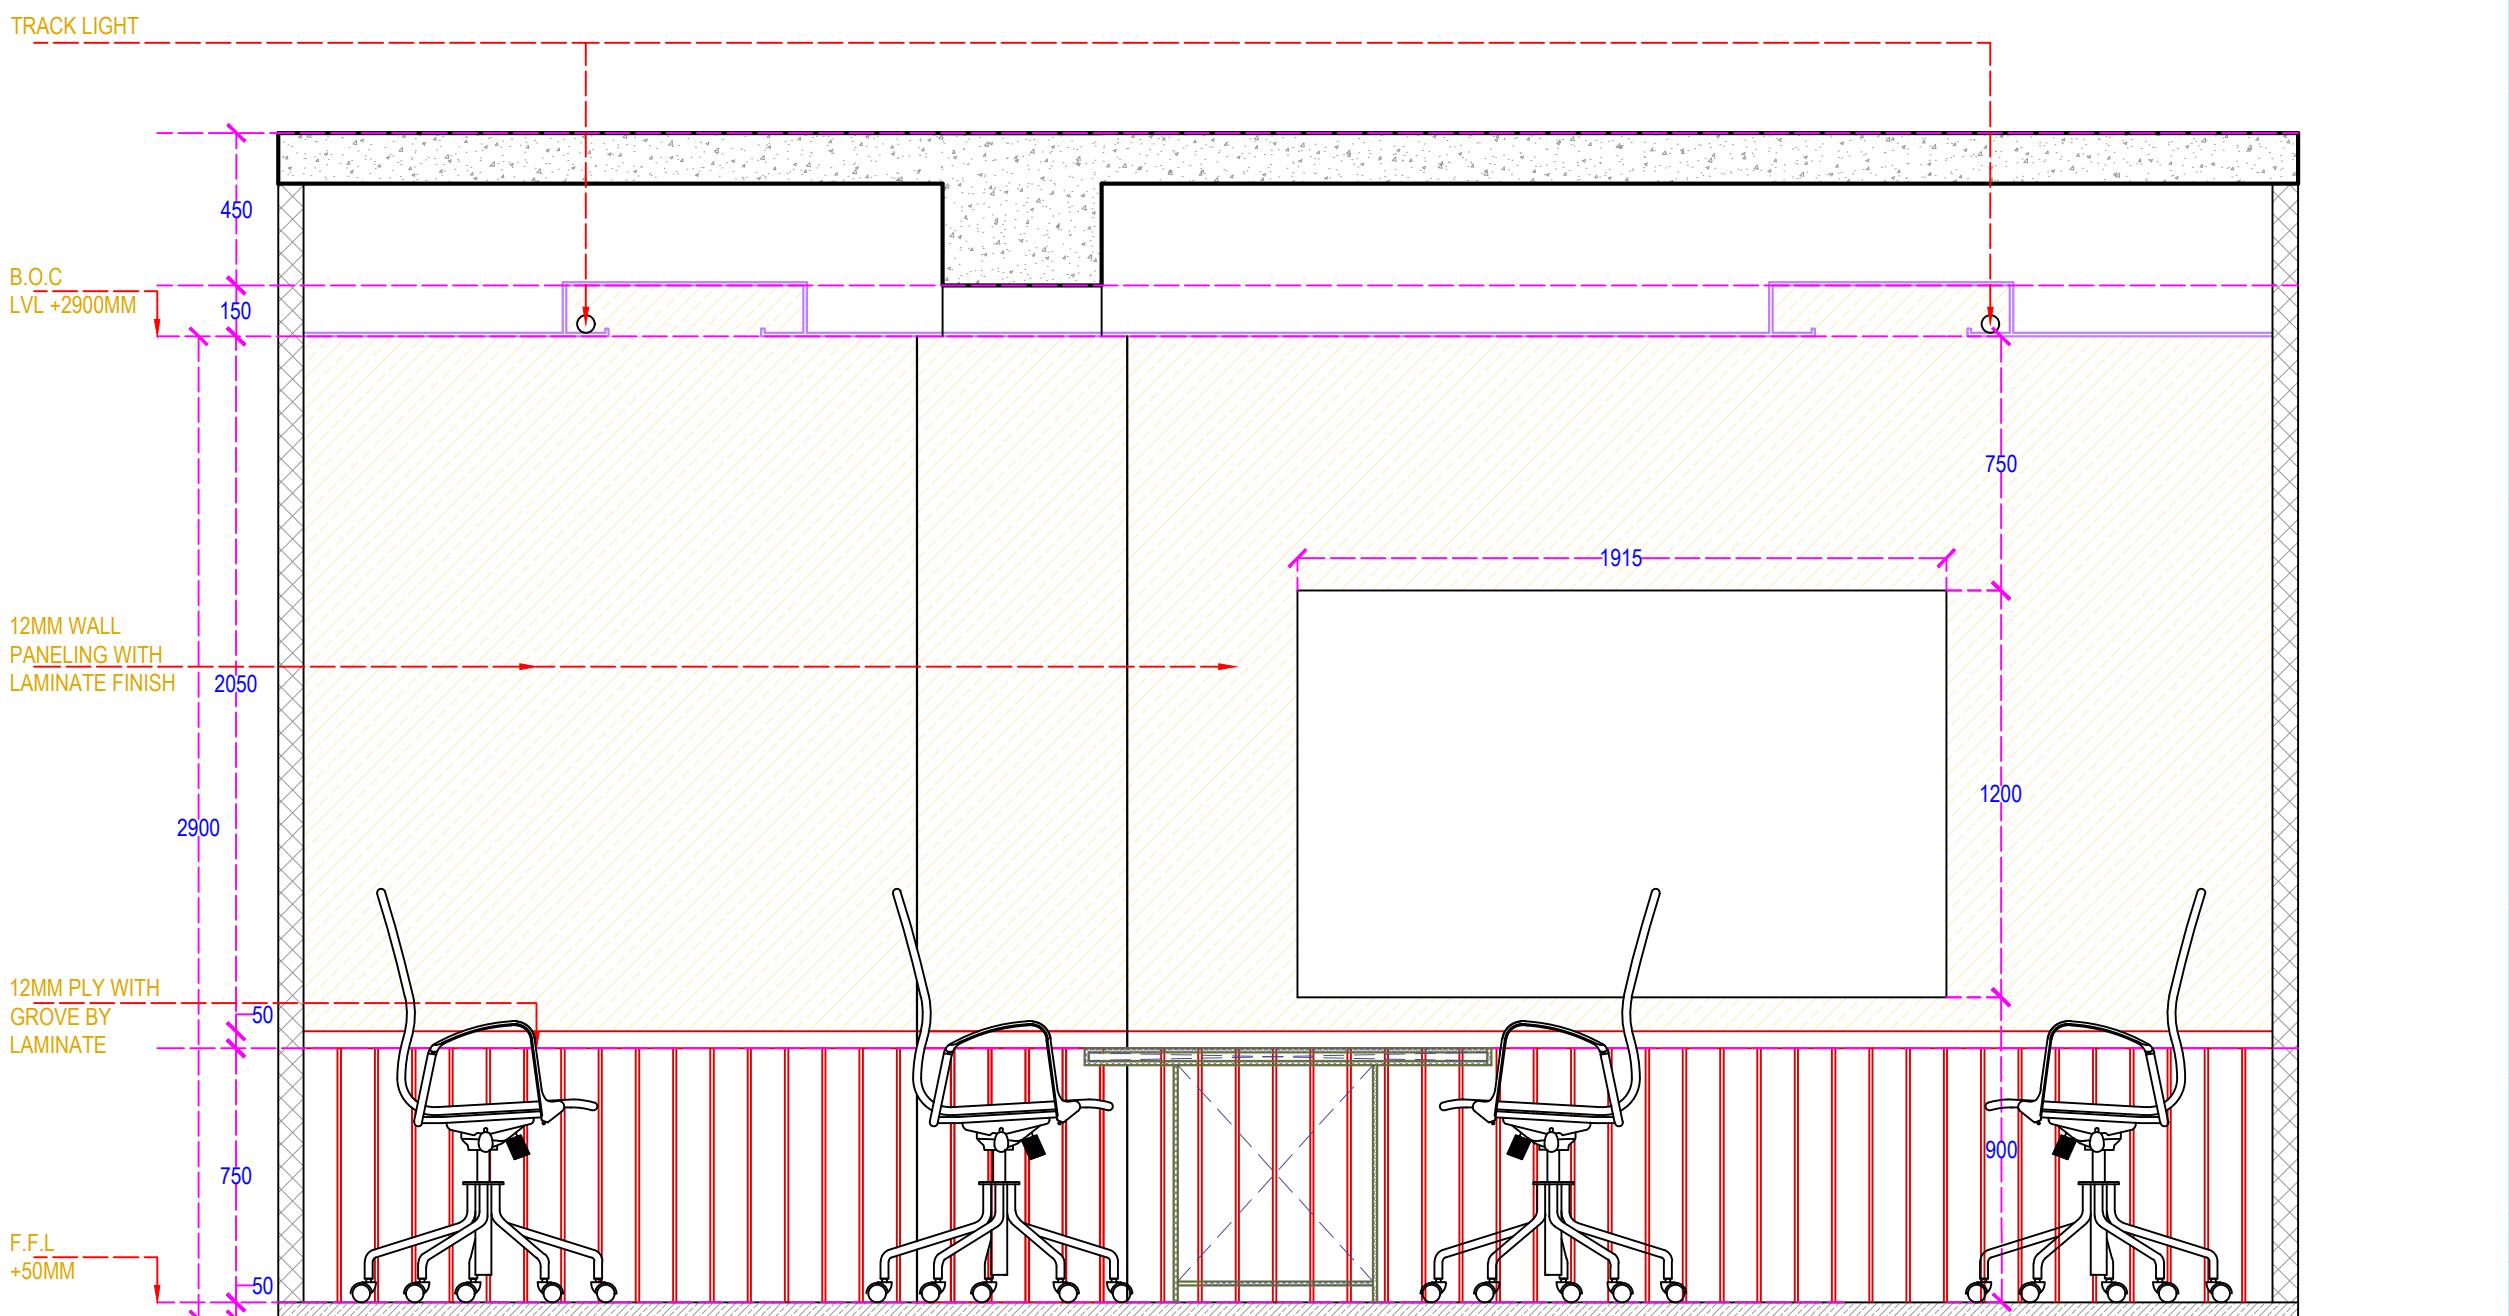

ELEVATION A

1

2


3

4



5

6

7

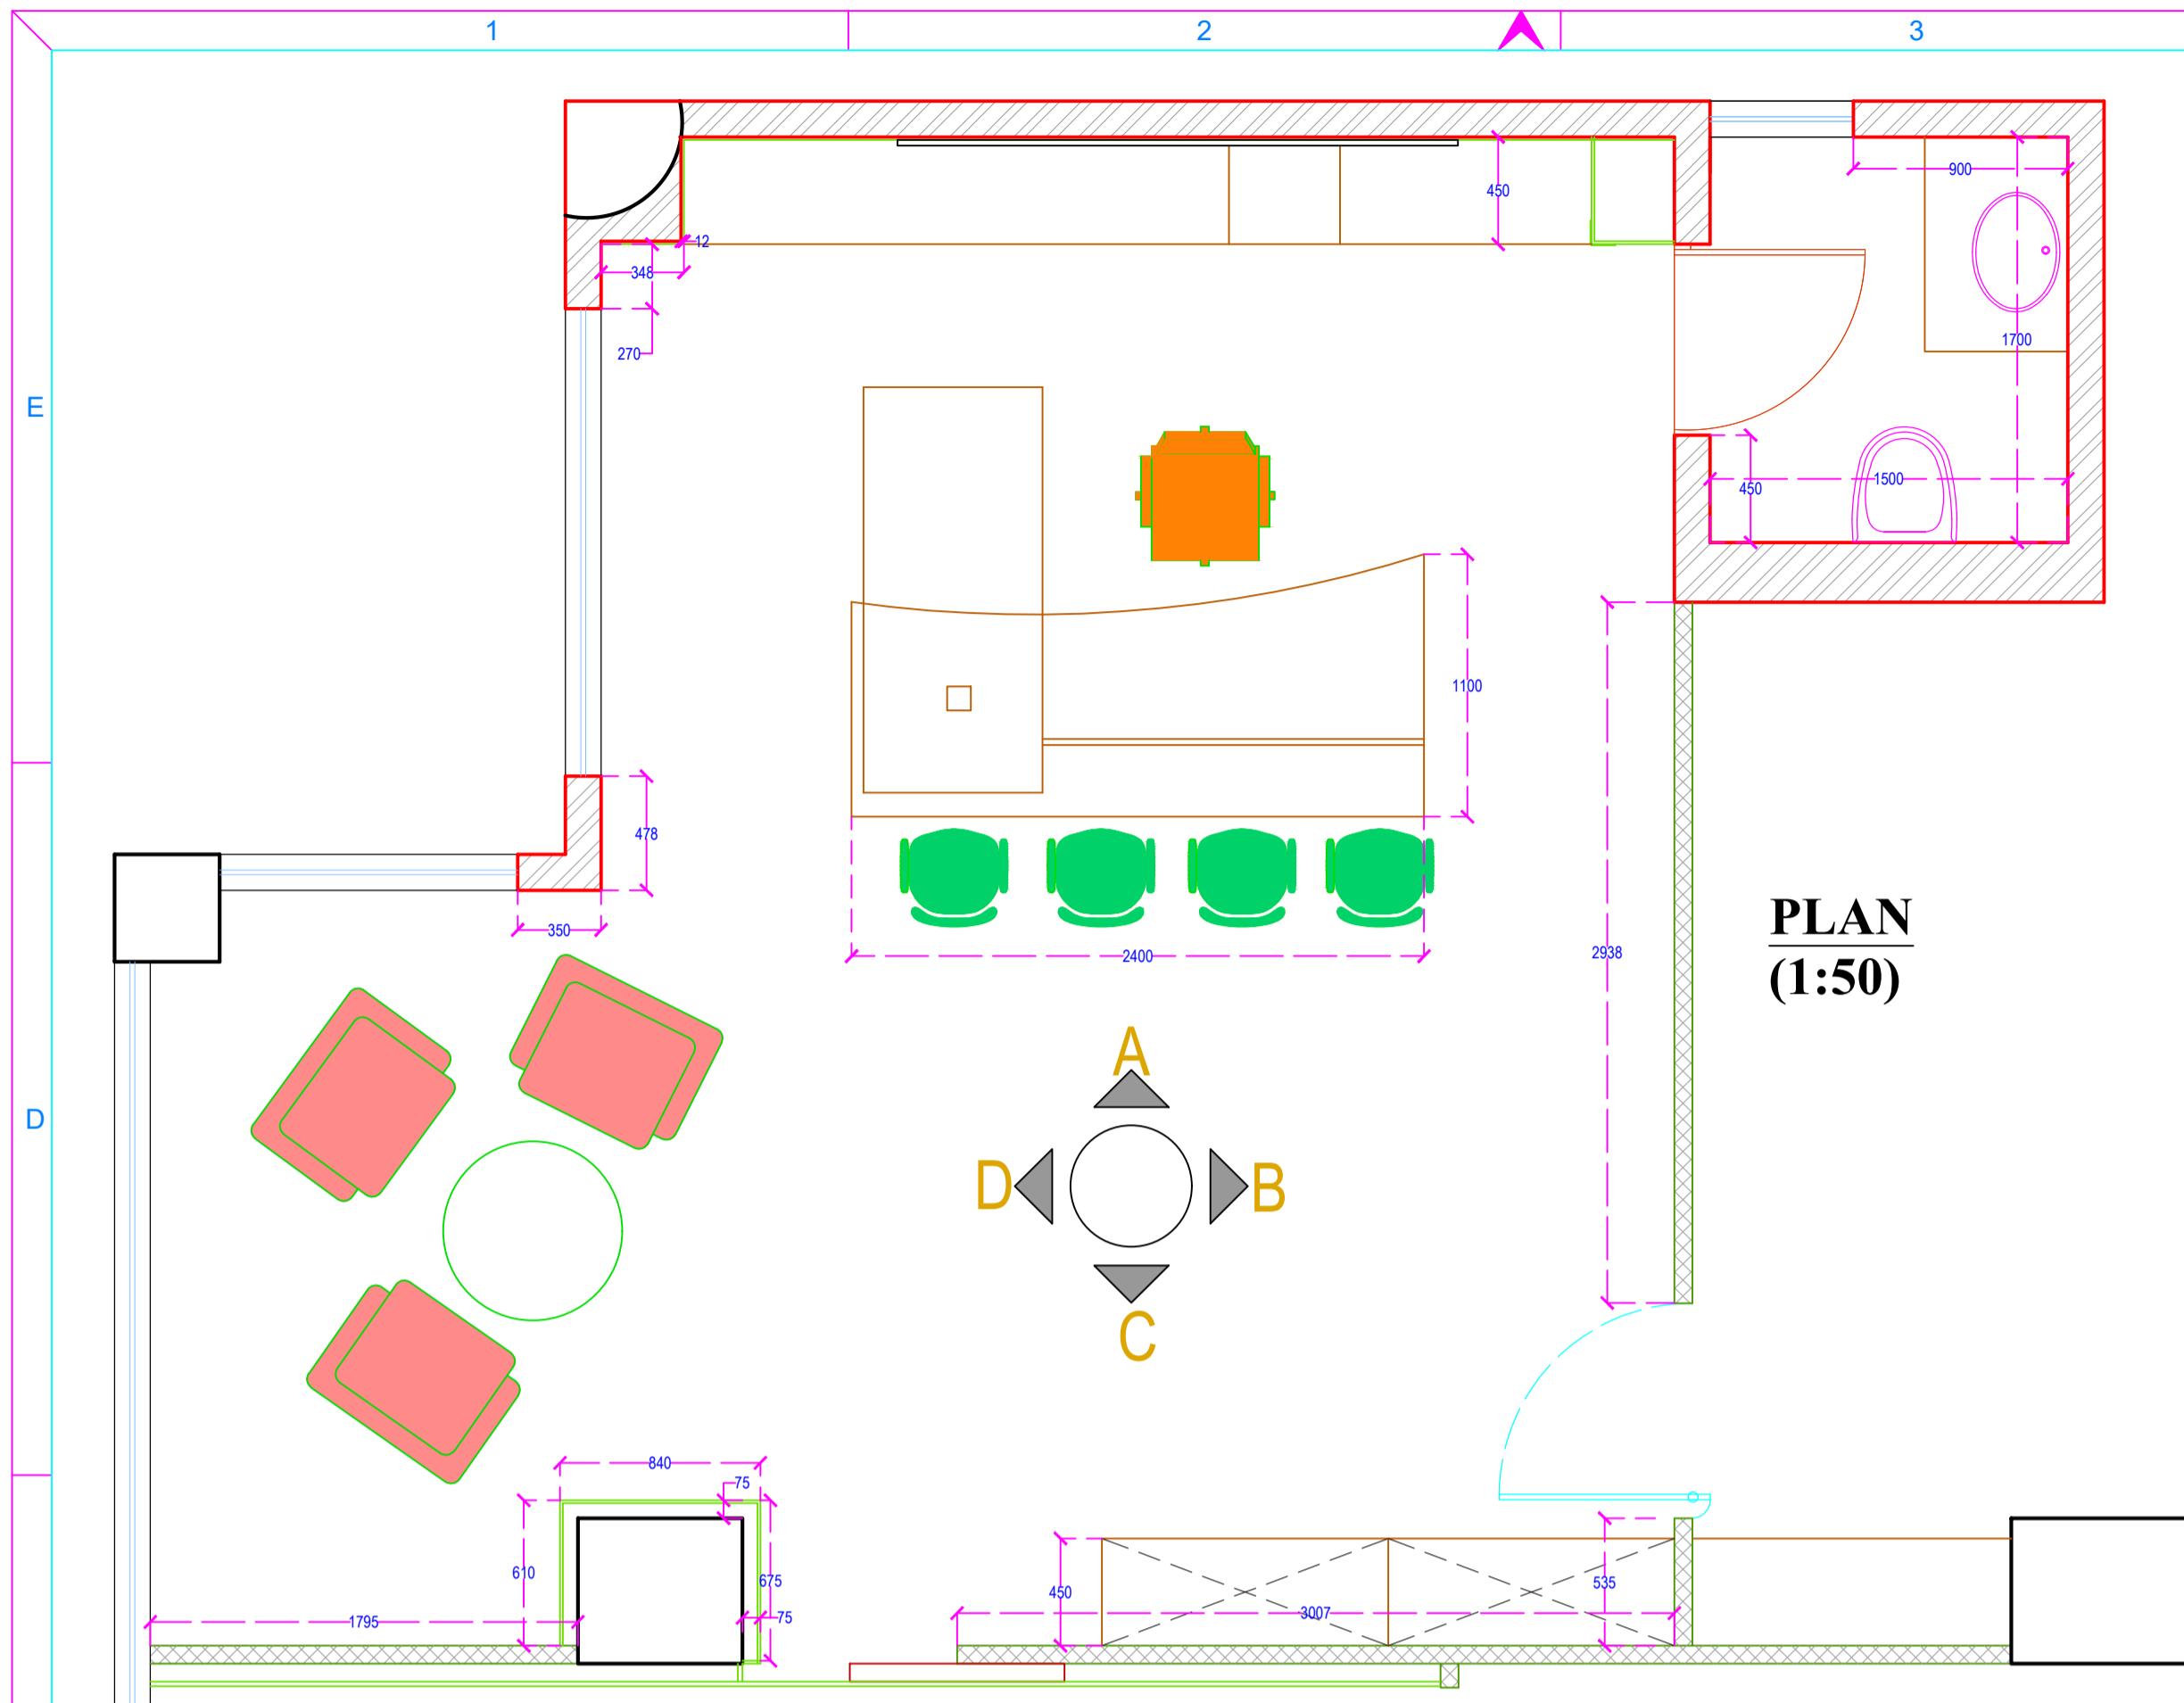

PLAN (1:50)

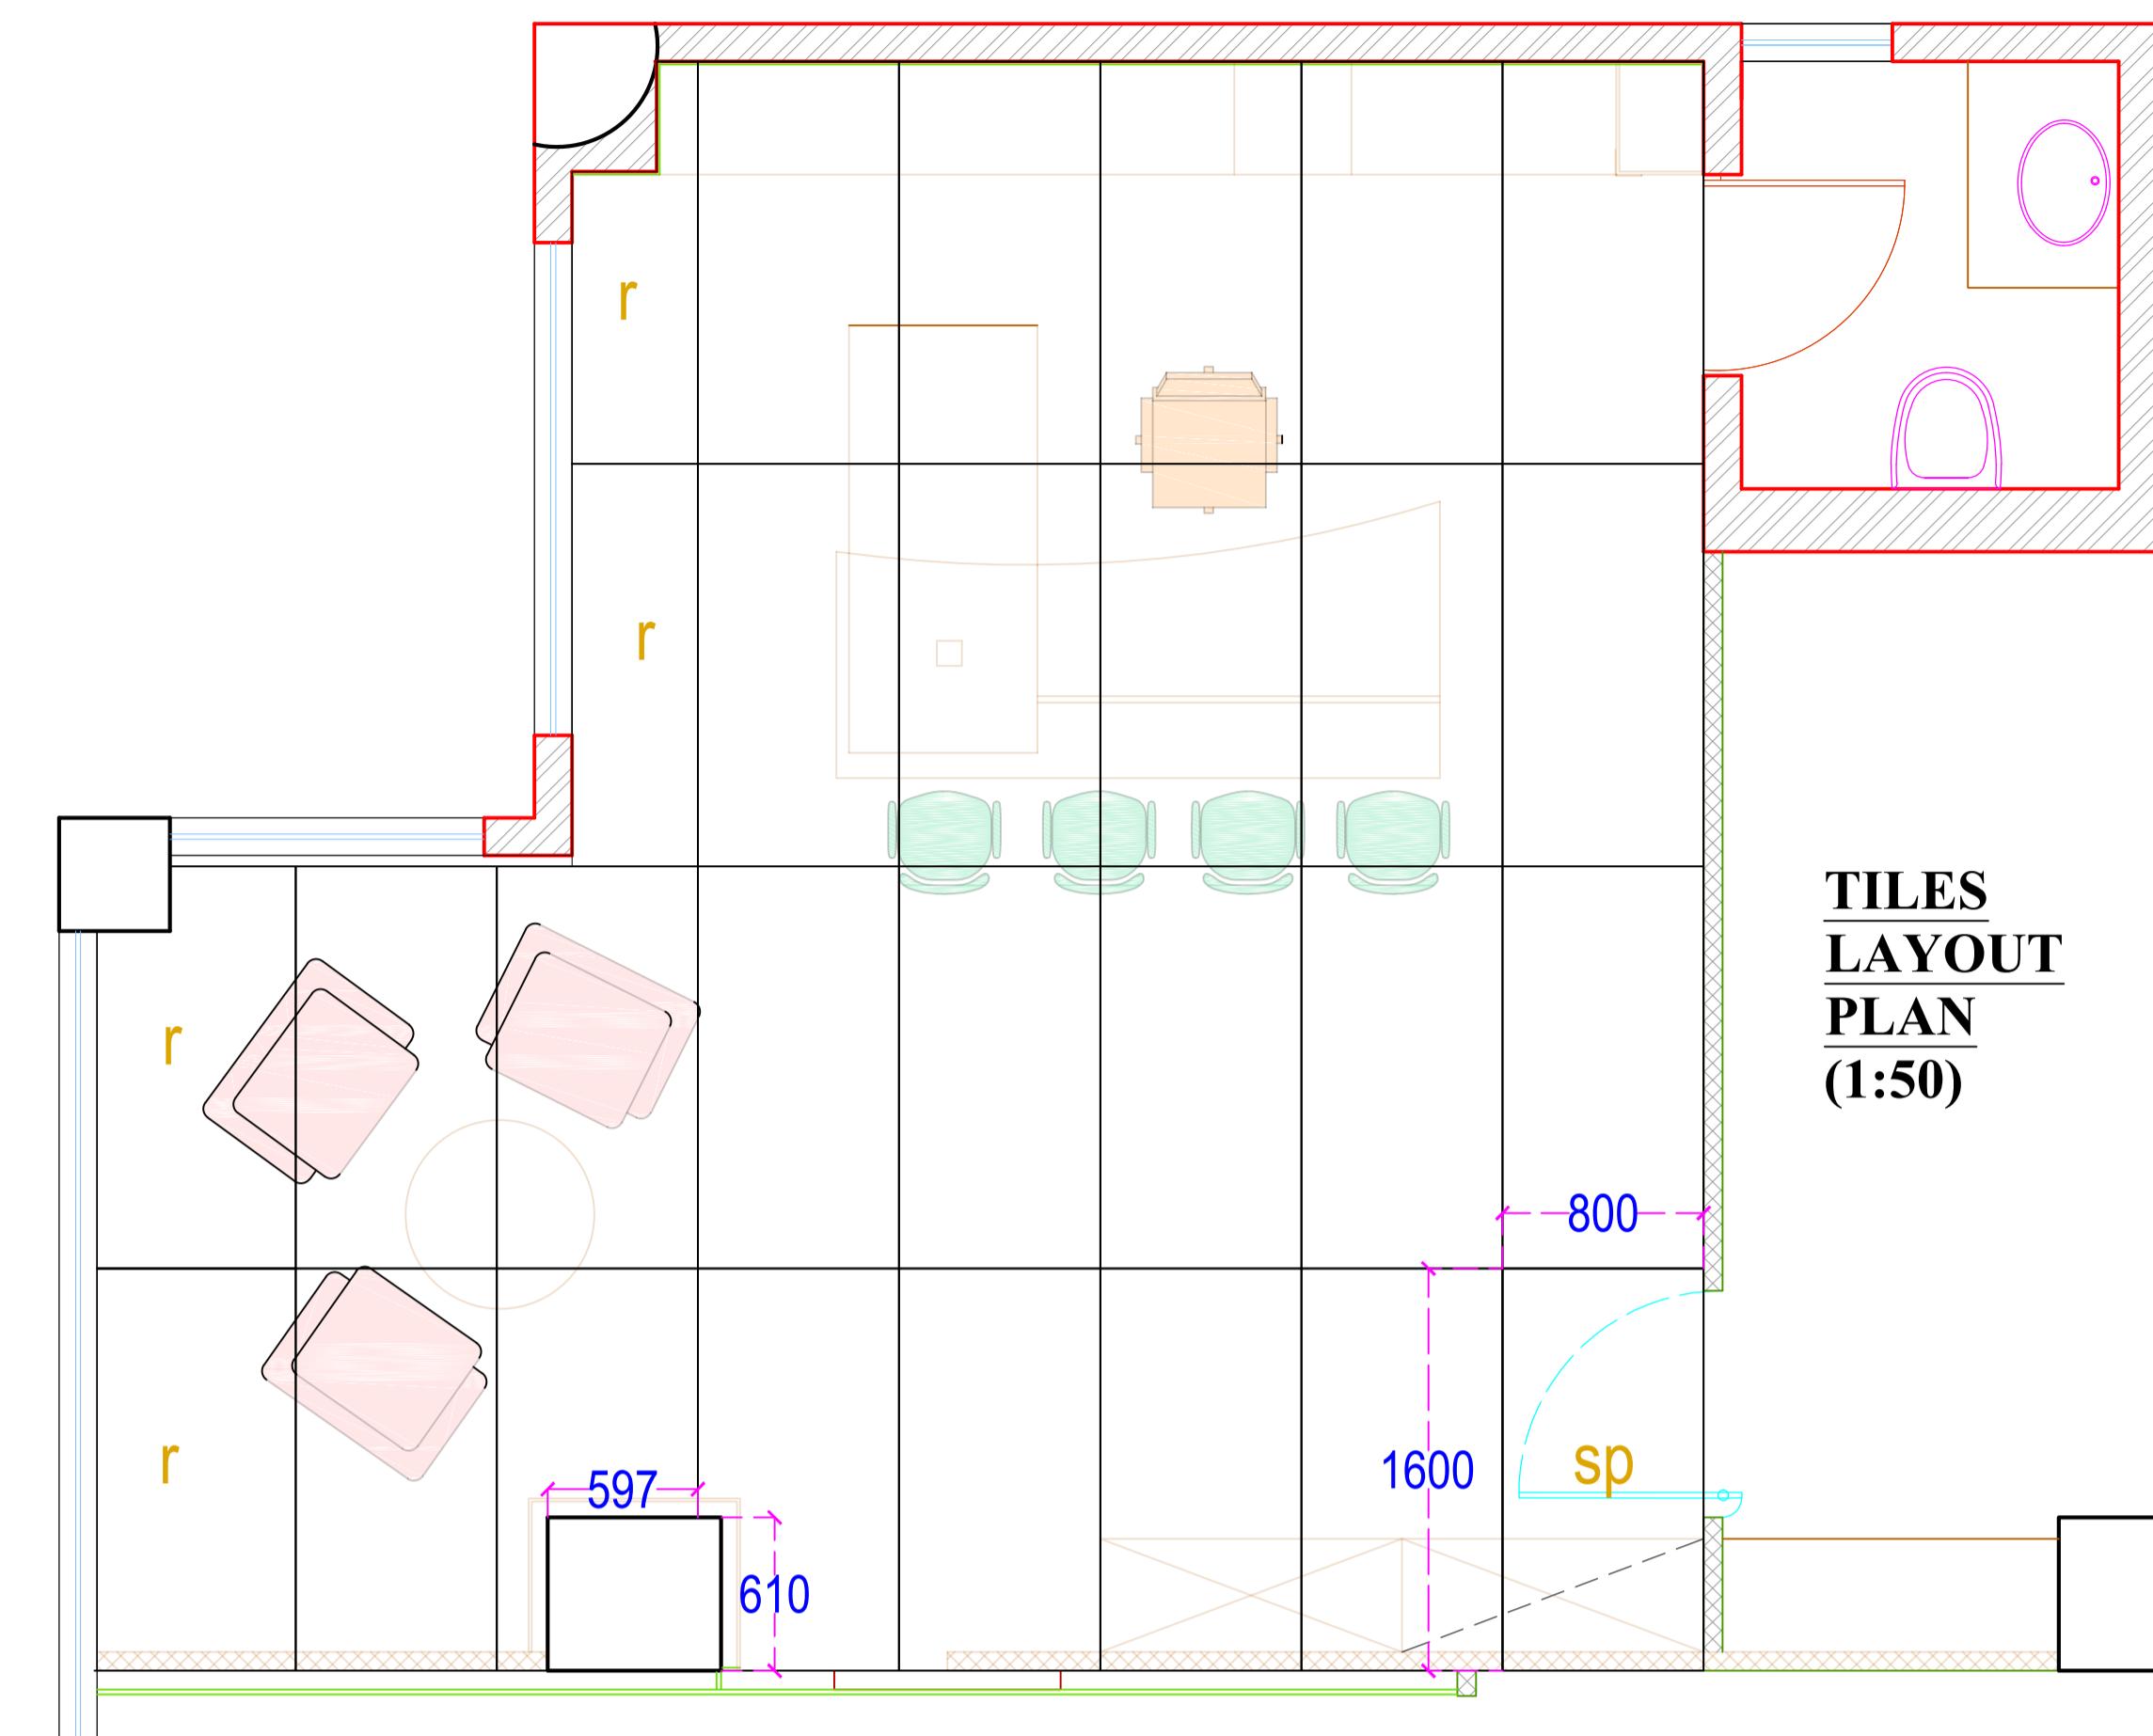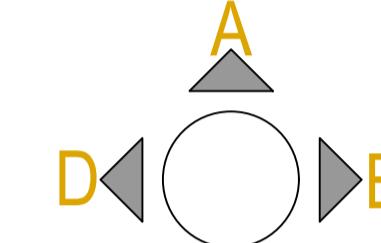

TILES LAYOUT PLAN (1:50)

CONSULTANT:




Consultant by **BASIC CONSULTANT** Engineers & Consultants


CLIENT

Assam Inland Water Transport Development Society.

Architectural and engineering services for setting-up of office of Assam Inland Water Transport Regulatory Authority (AIWTRA) & Office of Assam Inland Water Company Ltd. (AIWCL) at directorate of IWT'S existing office building premises at Ulubari, Guwahati (Assam).

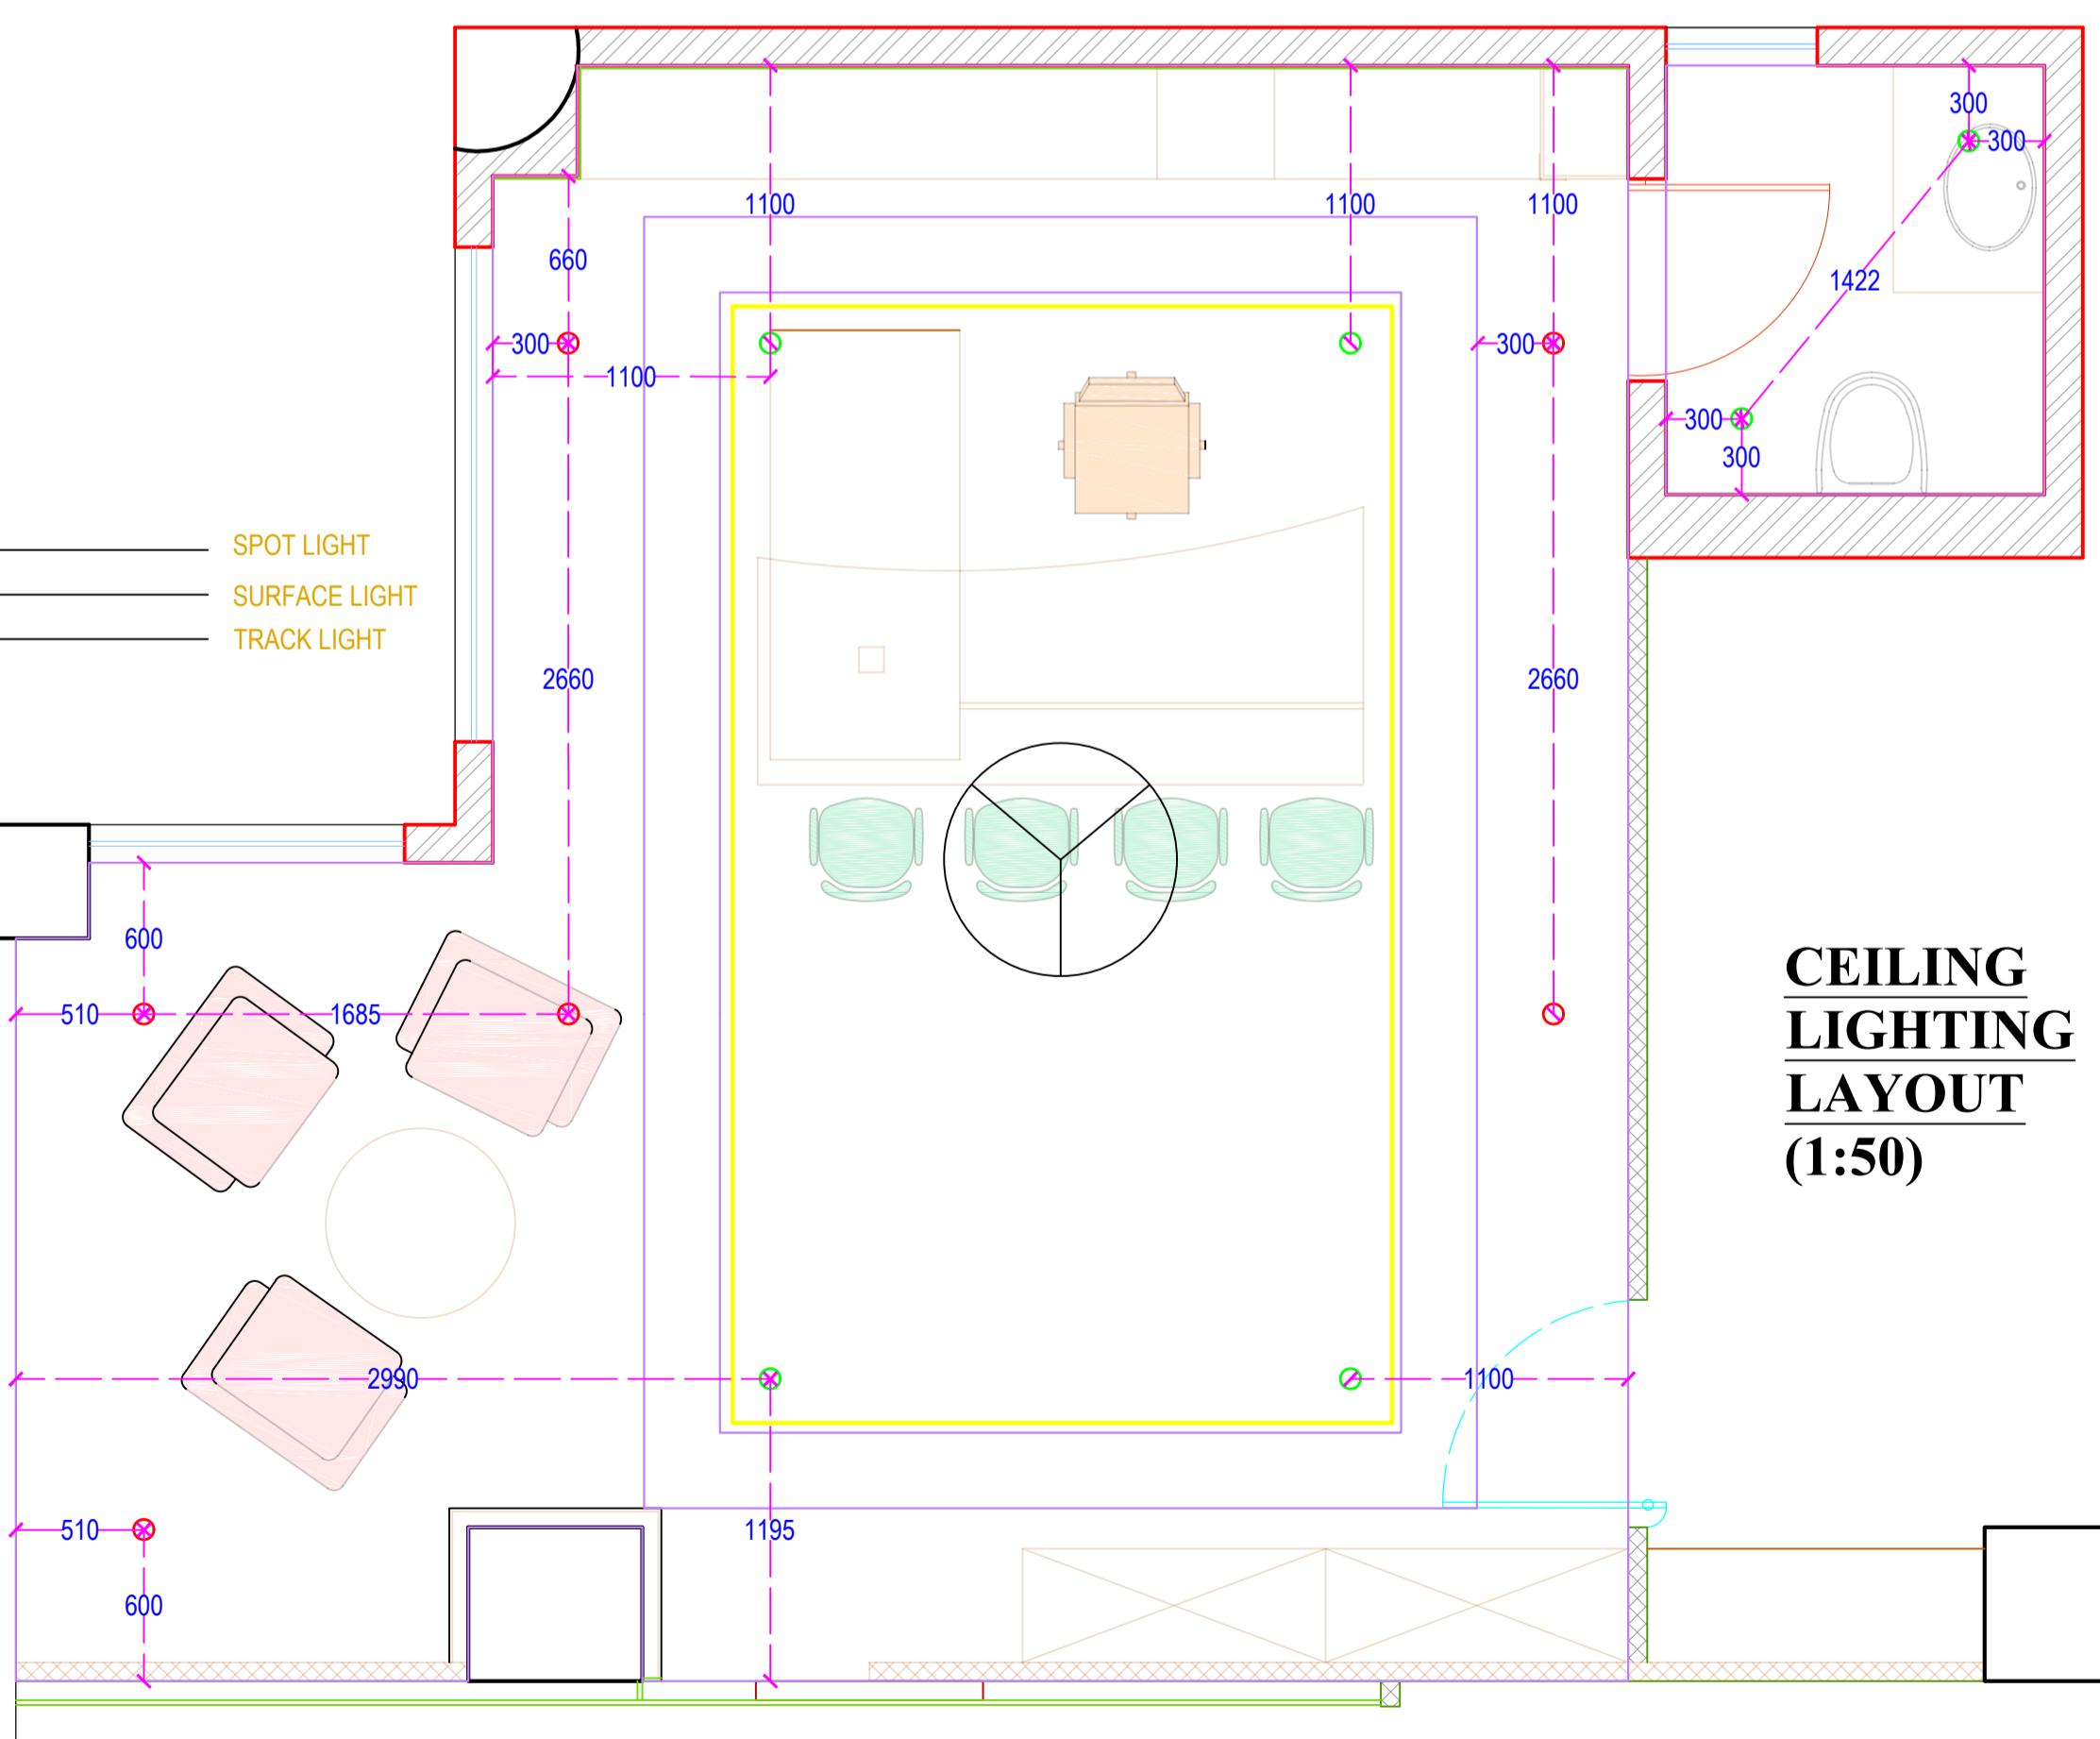

CEILING LIGHTING AYOUT (1:50)

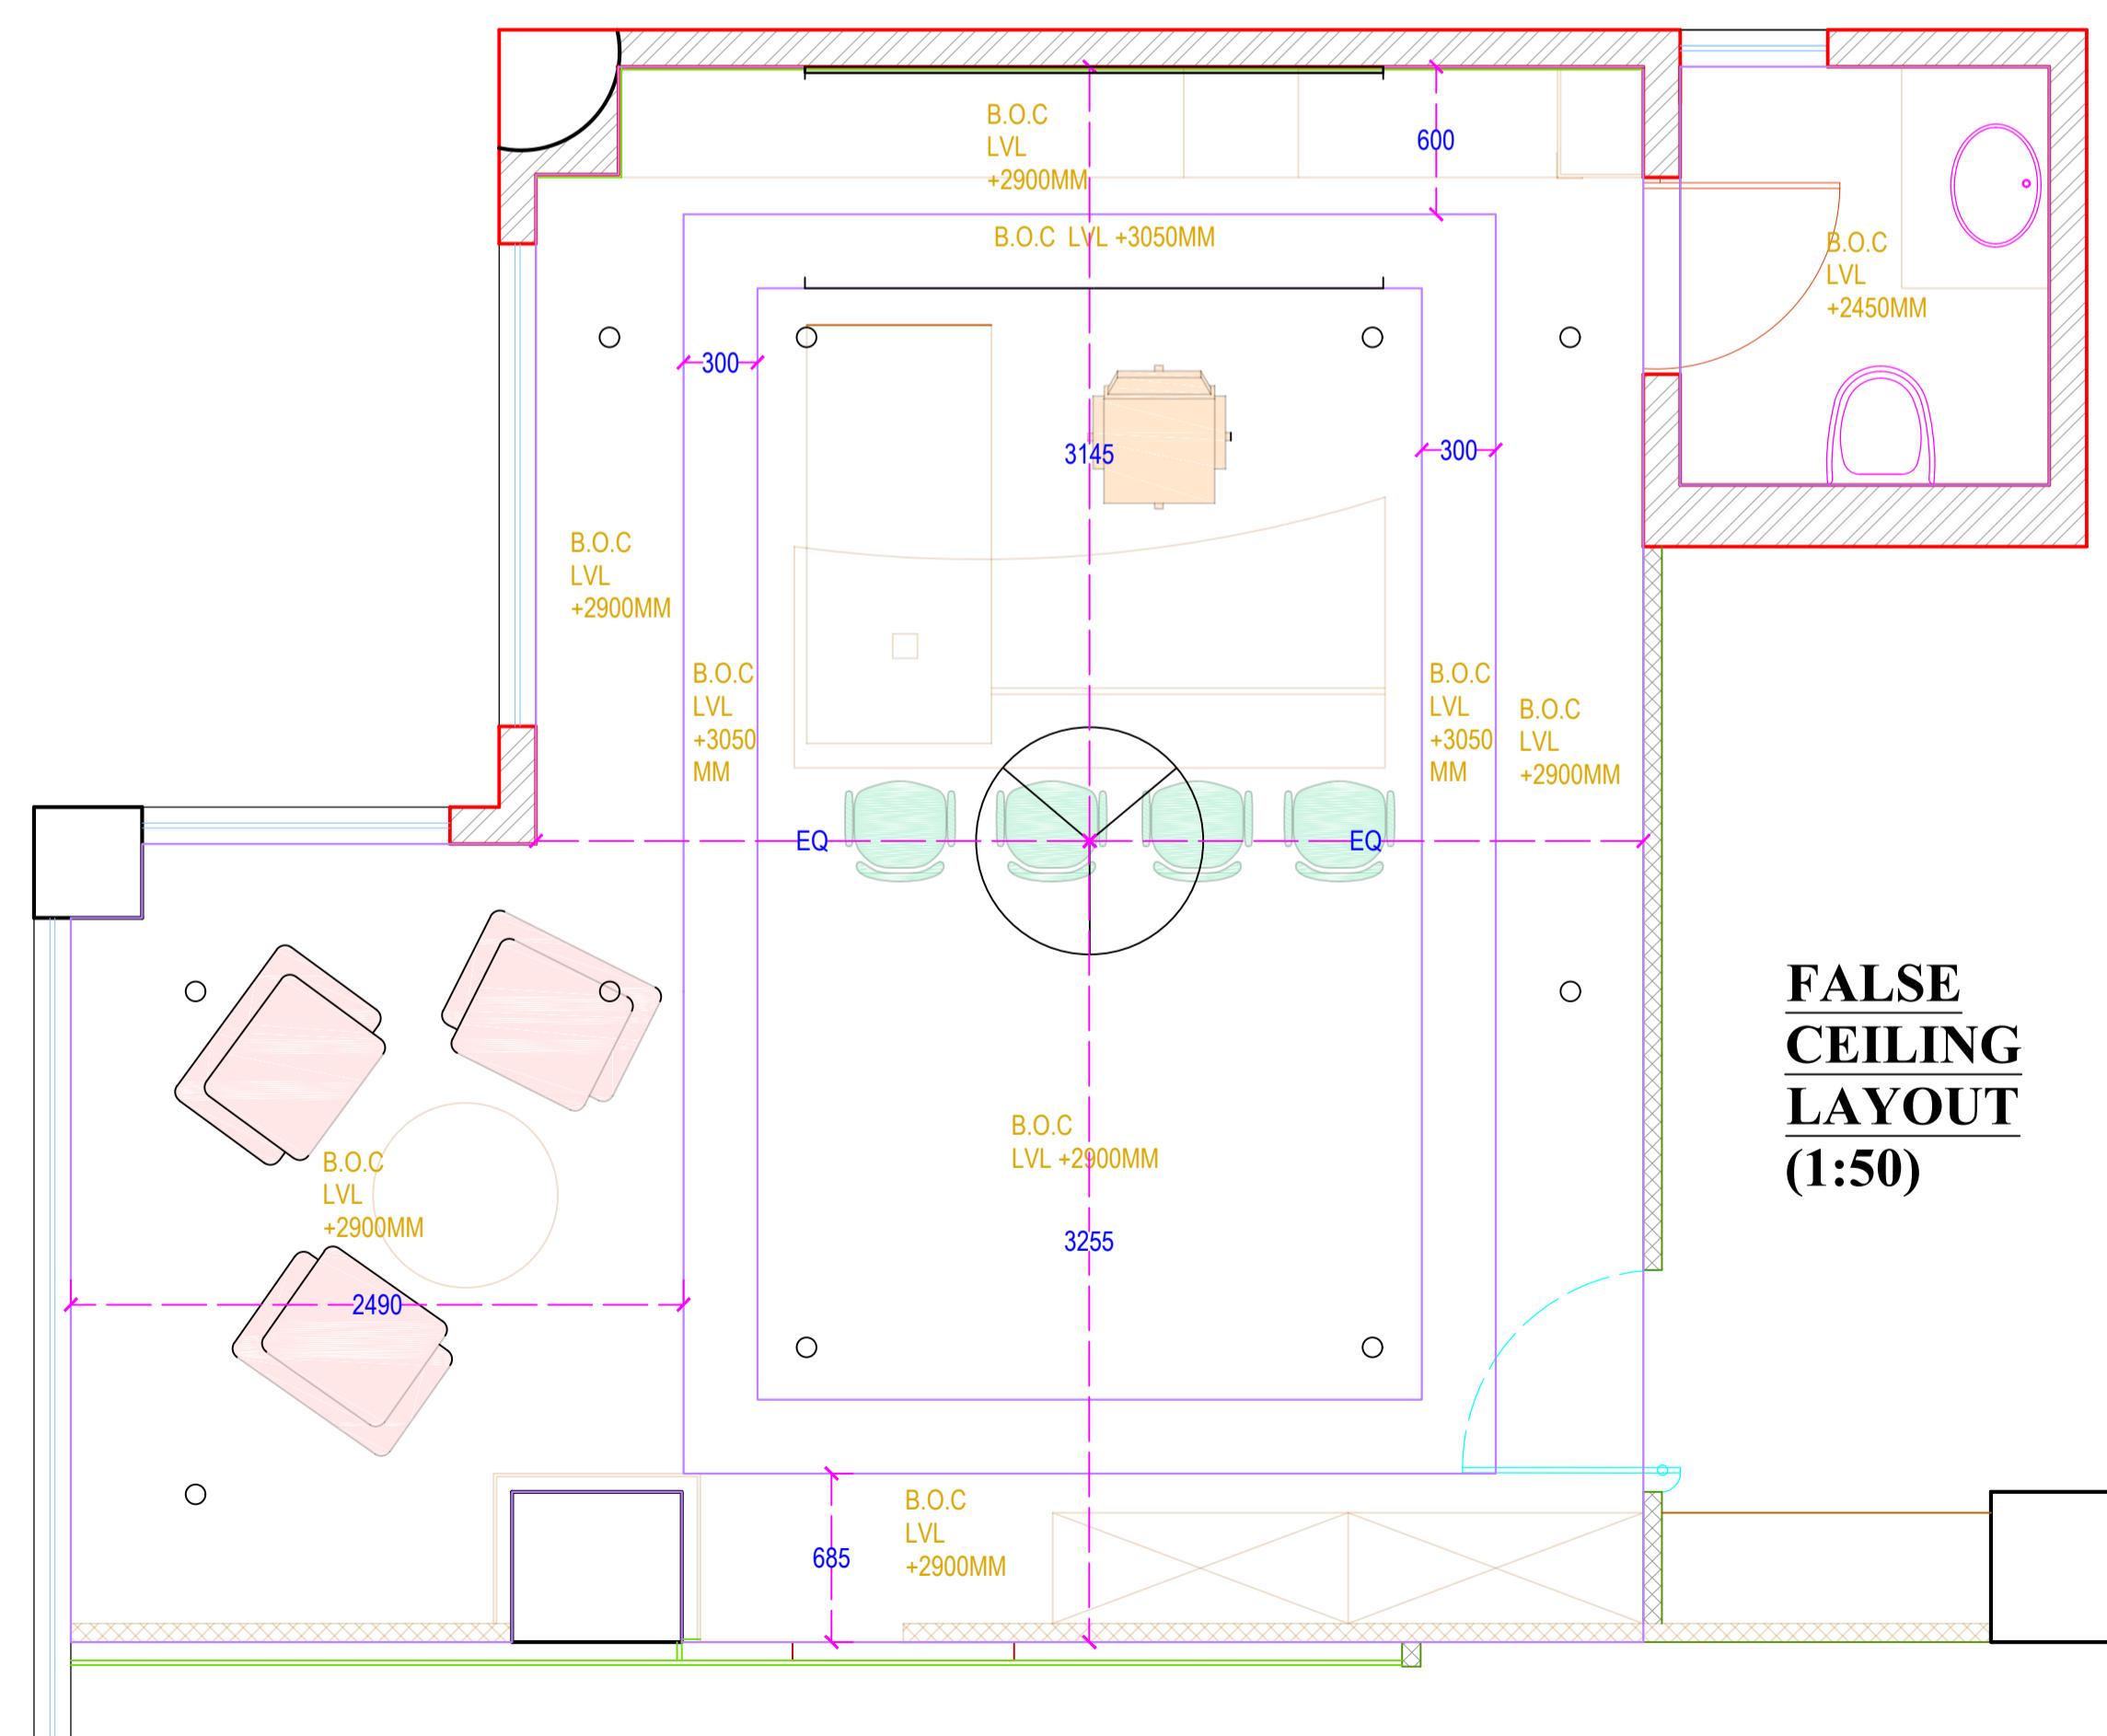

FALSE CEILING LAYOUT (1:50)

Assam Inland Water Transport Development Project.

DRAWING TITLE
DIRECTOR ROOM

DISCIPLINE: RENOVATION

STATUS DP

FILE NAME:

DESIGNED: DRAWN:

dhruv	sahra
APPROVED:	CHECKED:

concerned dhruv


DATE: 04/09/23

GOV. 22/02

1. **What is the primary purpose of the study?** (e.g., to evaluate the effectiveness of a new treatment, to explore a new research question, to describe a population, etc.)

AI DRAWING

7

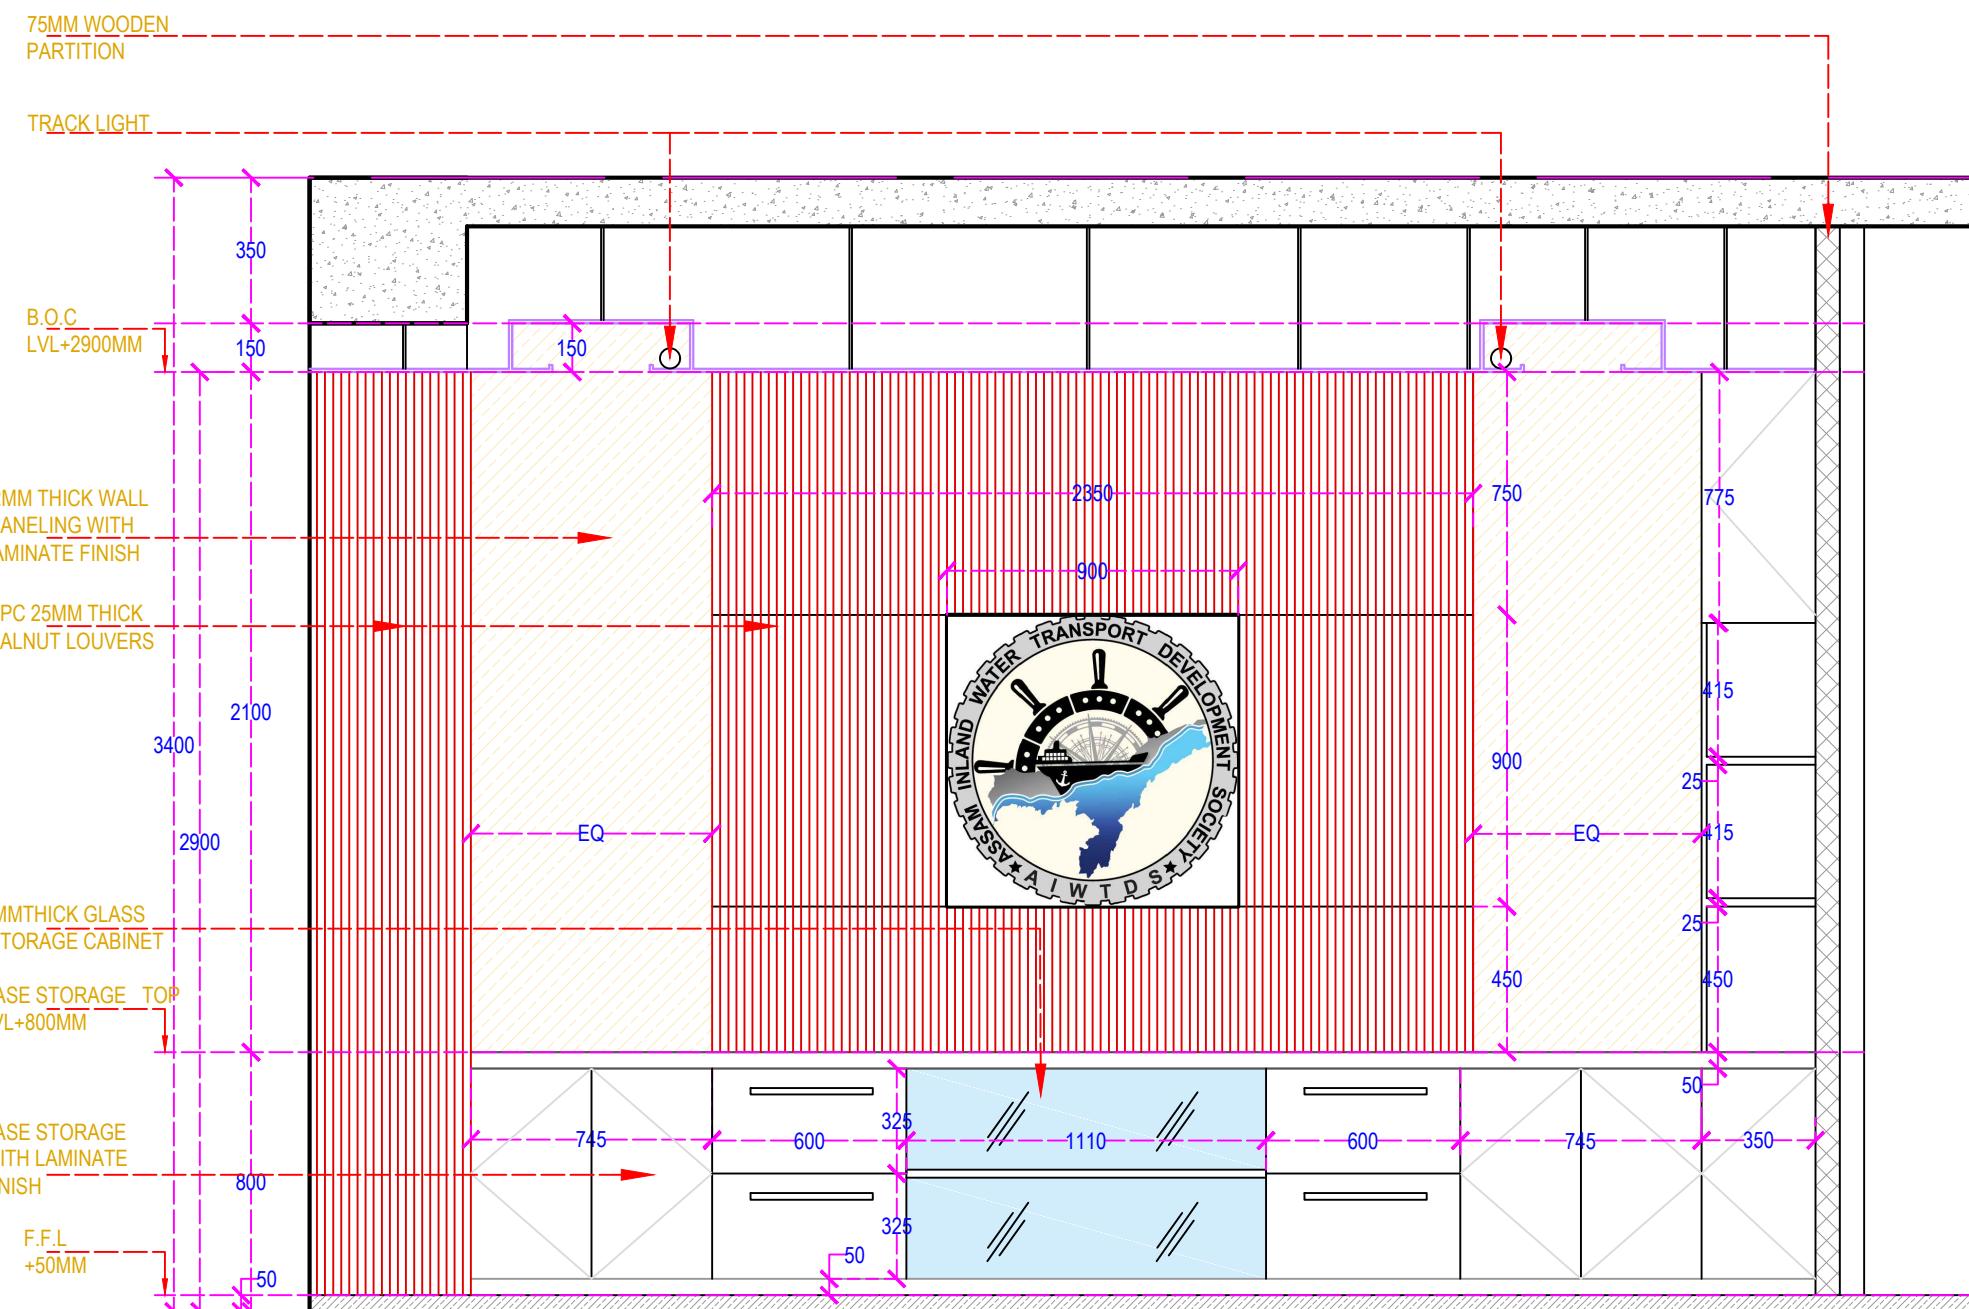

ELEVATION A

CONSULTANT:

**Consultant by
BASIC CONSULTANT
Engineers &Consultants**

CLIENT
**Assam Inland Water Transport
Development Society.**

**Architectural and engineering services
for setting-up of office of Assam Inland
Water Transport Regulatory Authority
(AIWTRA) & Office of Assam Inland
Water Company Ltd. (AIWCL) at
directorate of IWT'S existing office
building premises at Ulubari, Guwahati
(Assam).**

GENERAL NOTES:

1. ALL DIMENSIONS ARE IN MILLIMETERS AND LEVELS IN METERS.
2. THIS DRAWING IS NOT TO BE SCALED, FOLLOW WRITTEN DIMENSIONS.
3. ANY DISCREPANCY SHALL FIRST BE CLARIFIED WITH THE CONSULTANT/ARCHITECT BEFORE PROCEEDING ANY FURTHER.

PROJECT

Assam Inland Water Transport Development Project.

DRAWING TITLE

DIRECTOR ROOM

DISCIPLINE: RENOVATION

STATUS DPR


FILE NAME:


DESIGNED: dhruv DRAWN: samrat NORTH 

APPROVED: concerned CHECKED: dhruv

DATE: 04/09/23 SCALE 1:50


GOV. 22/02 A-01 R-00

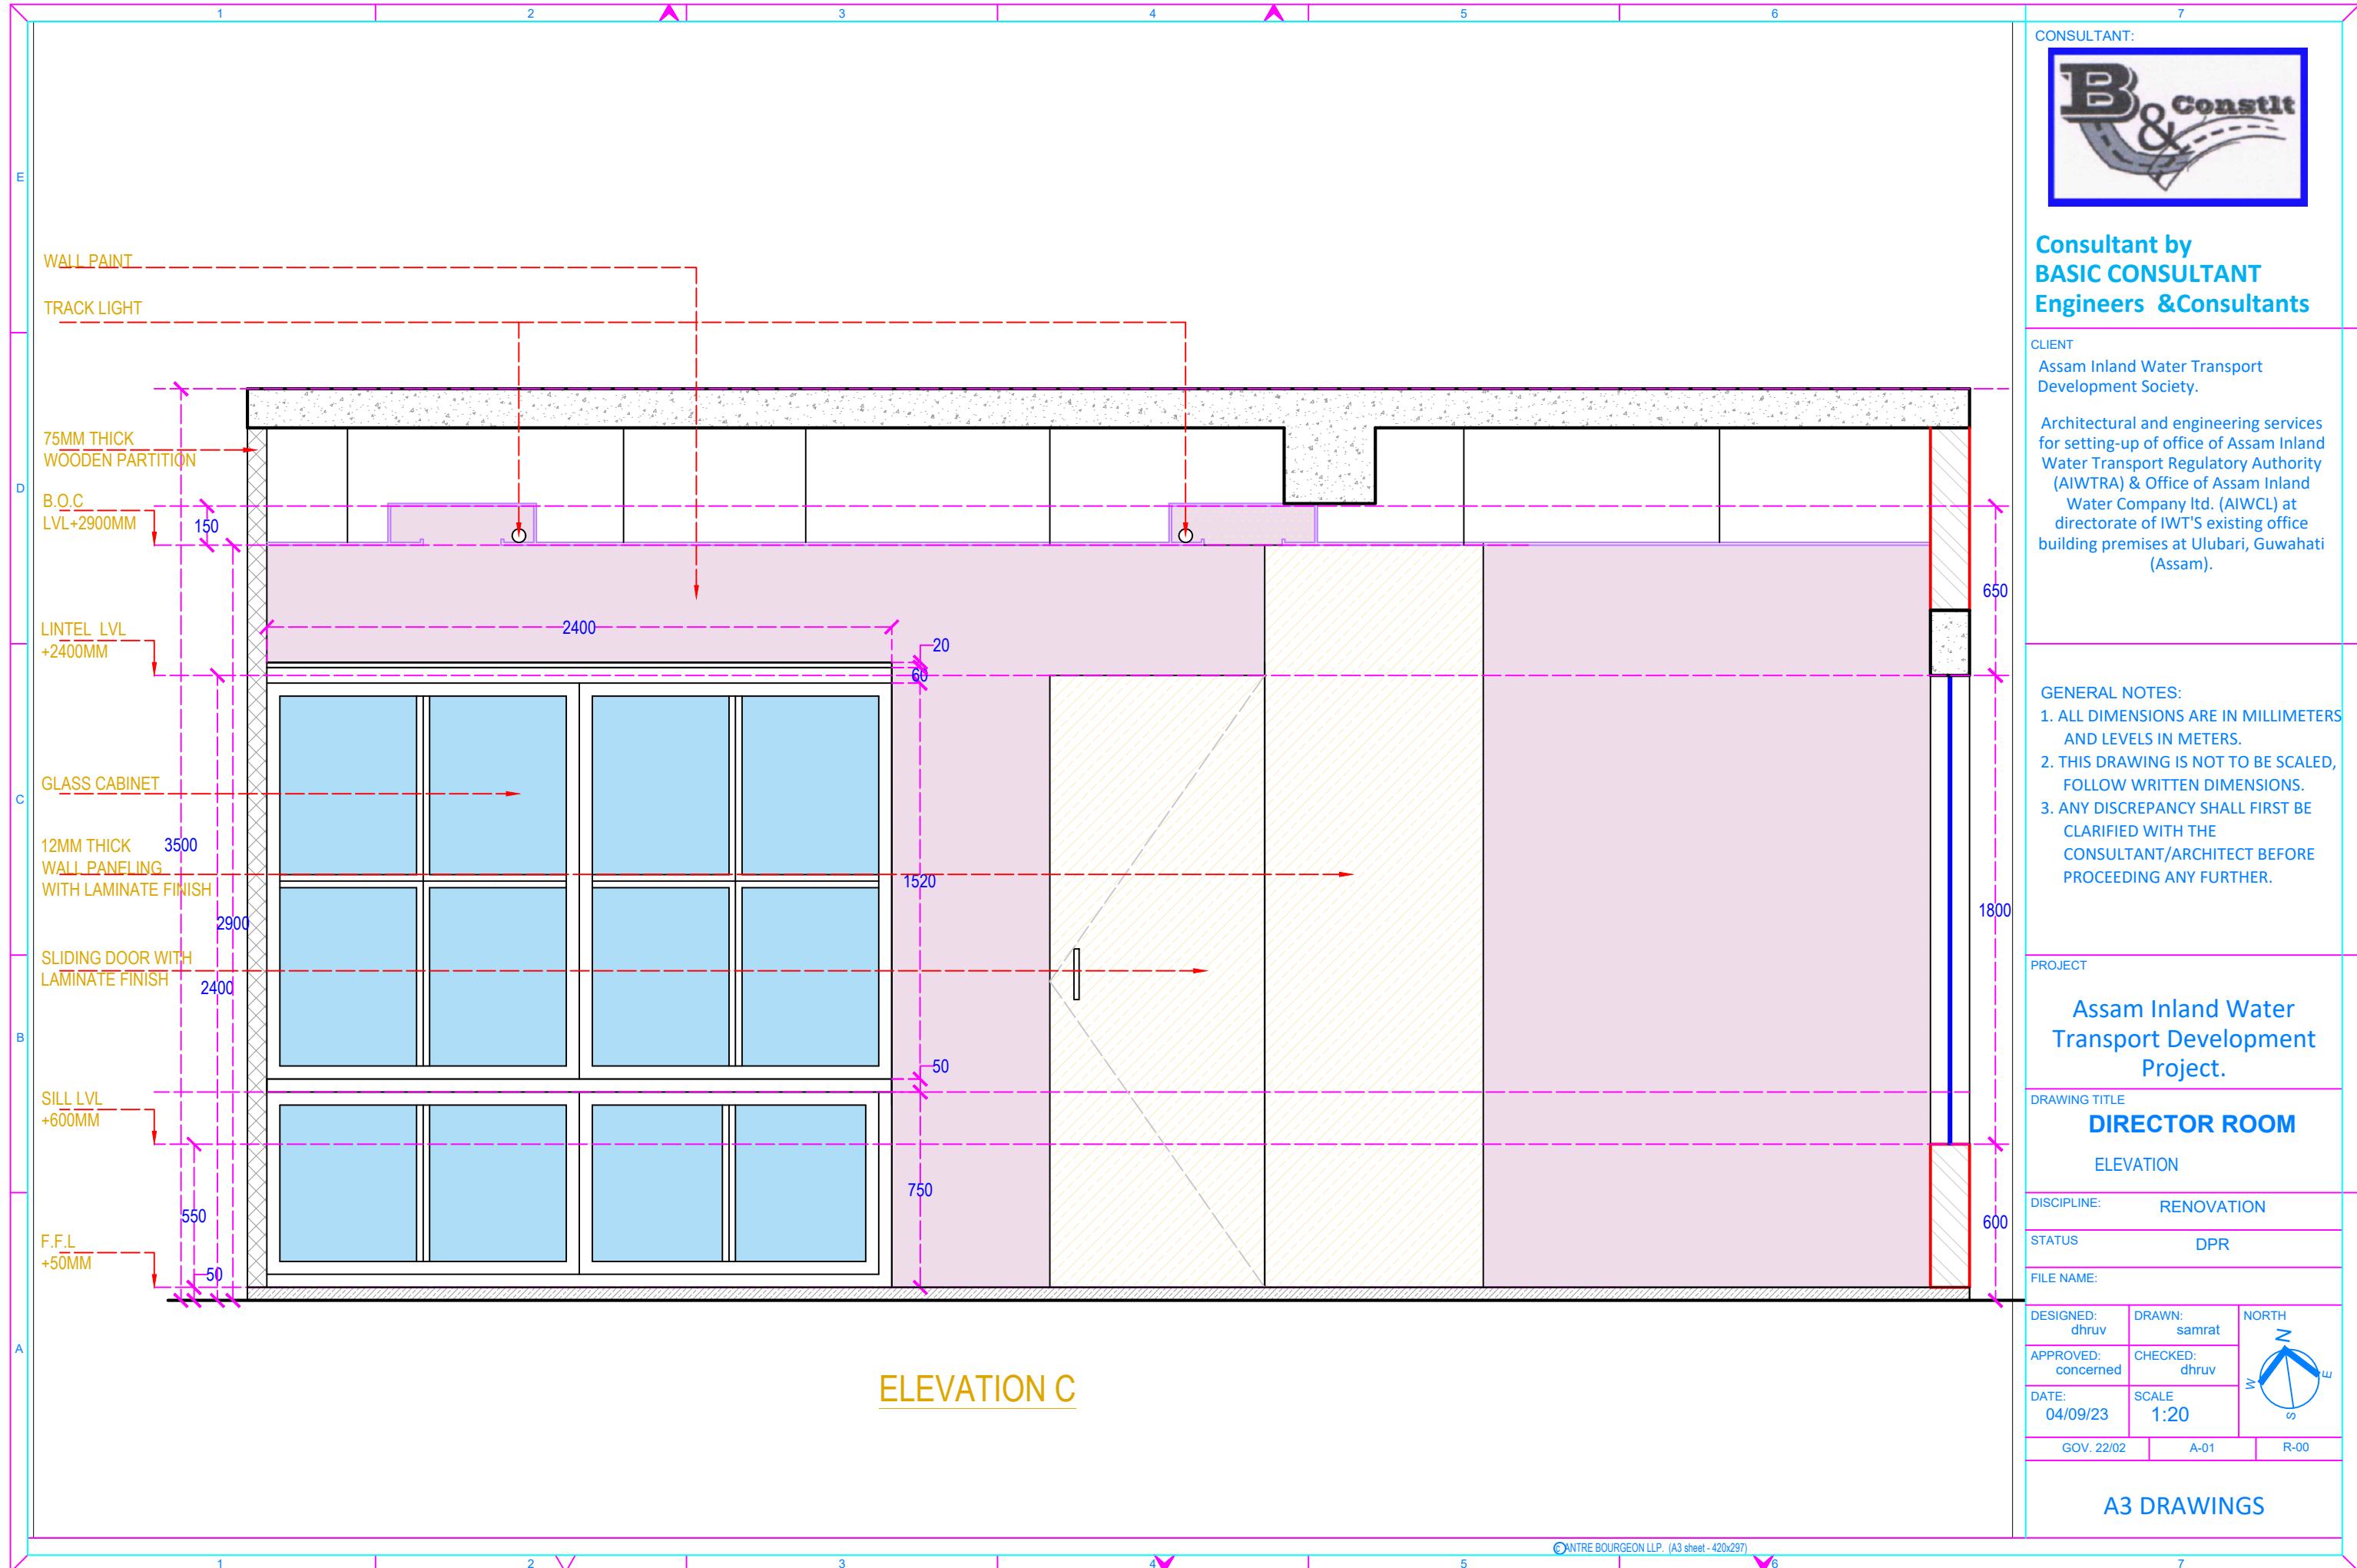

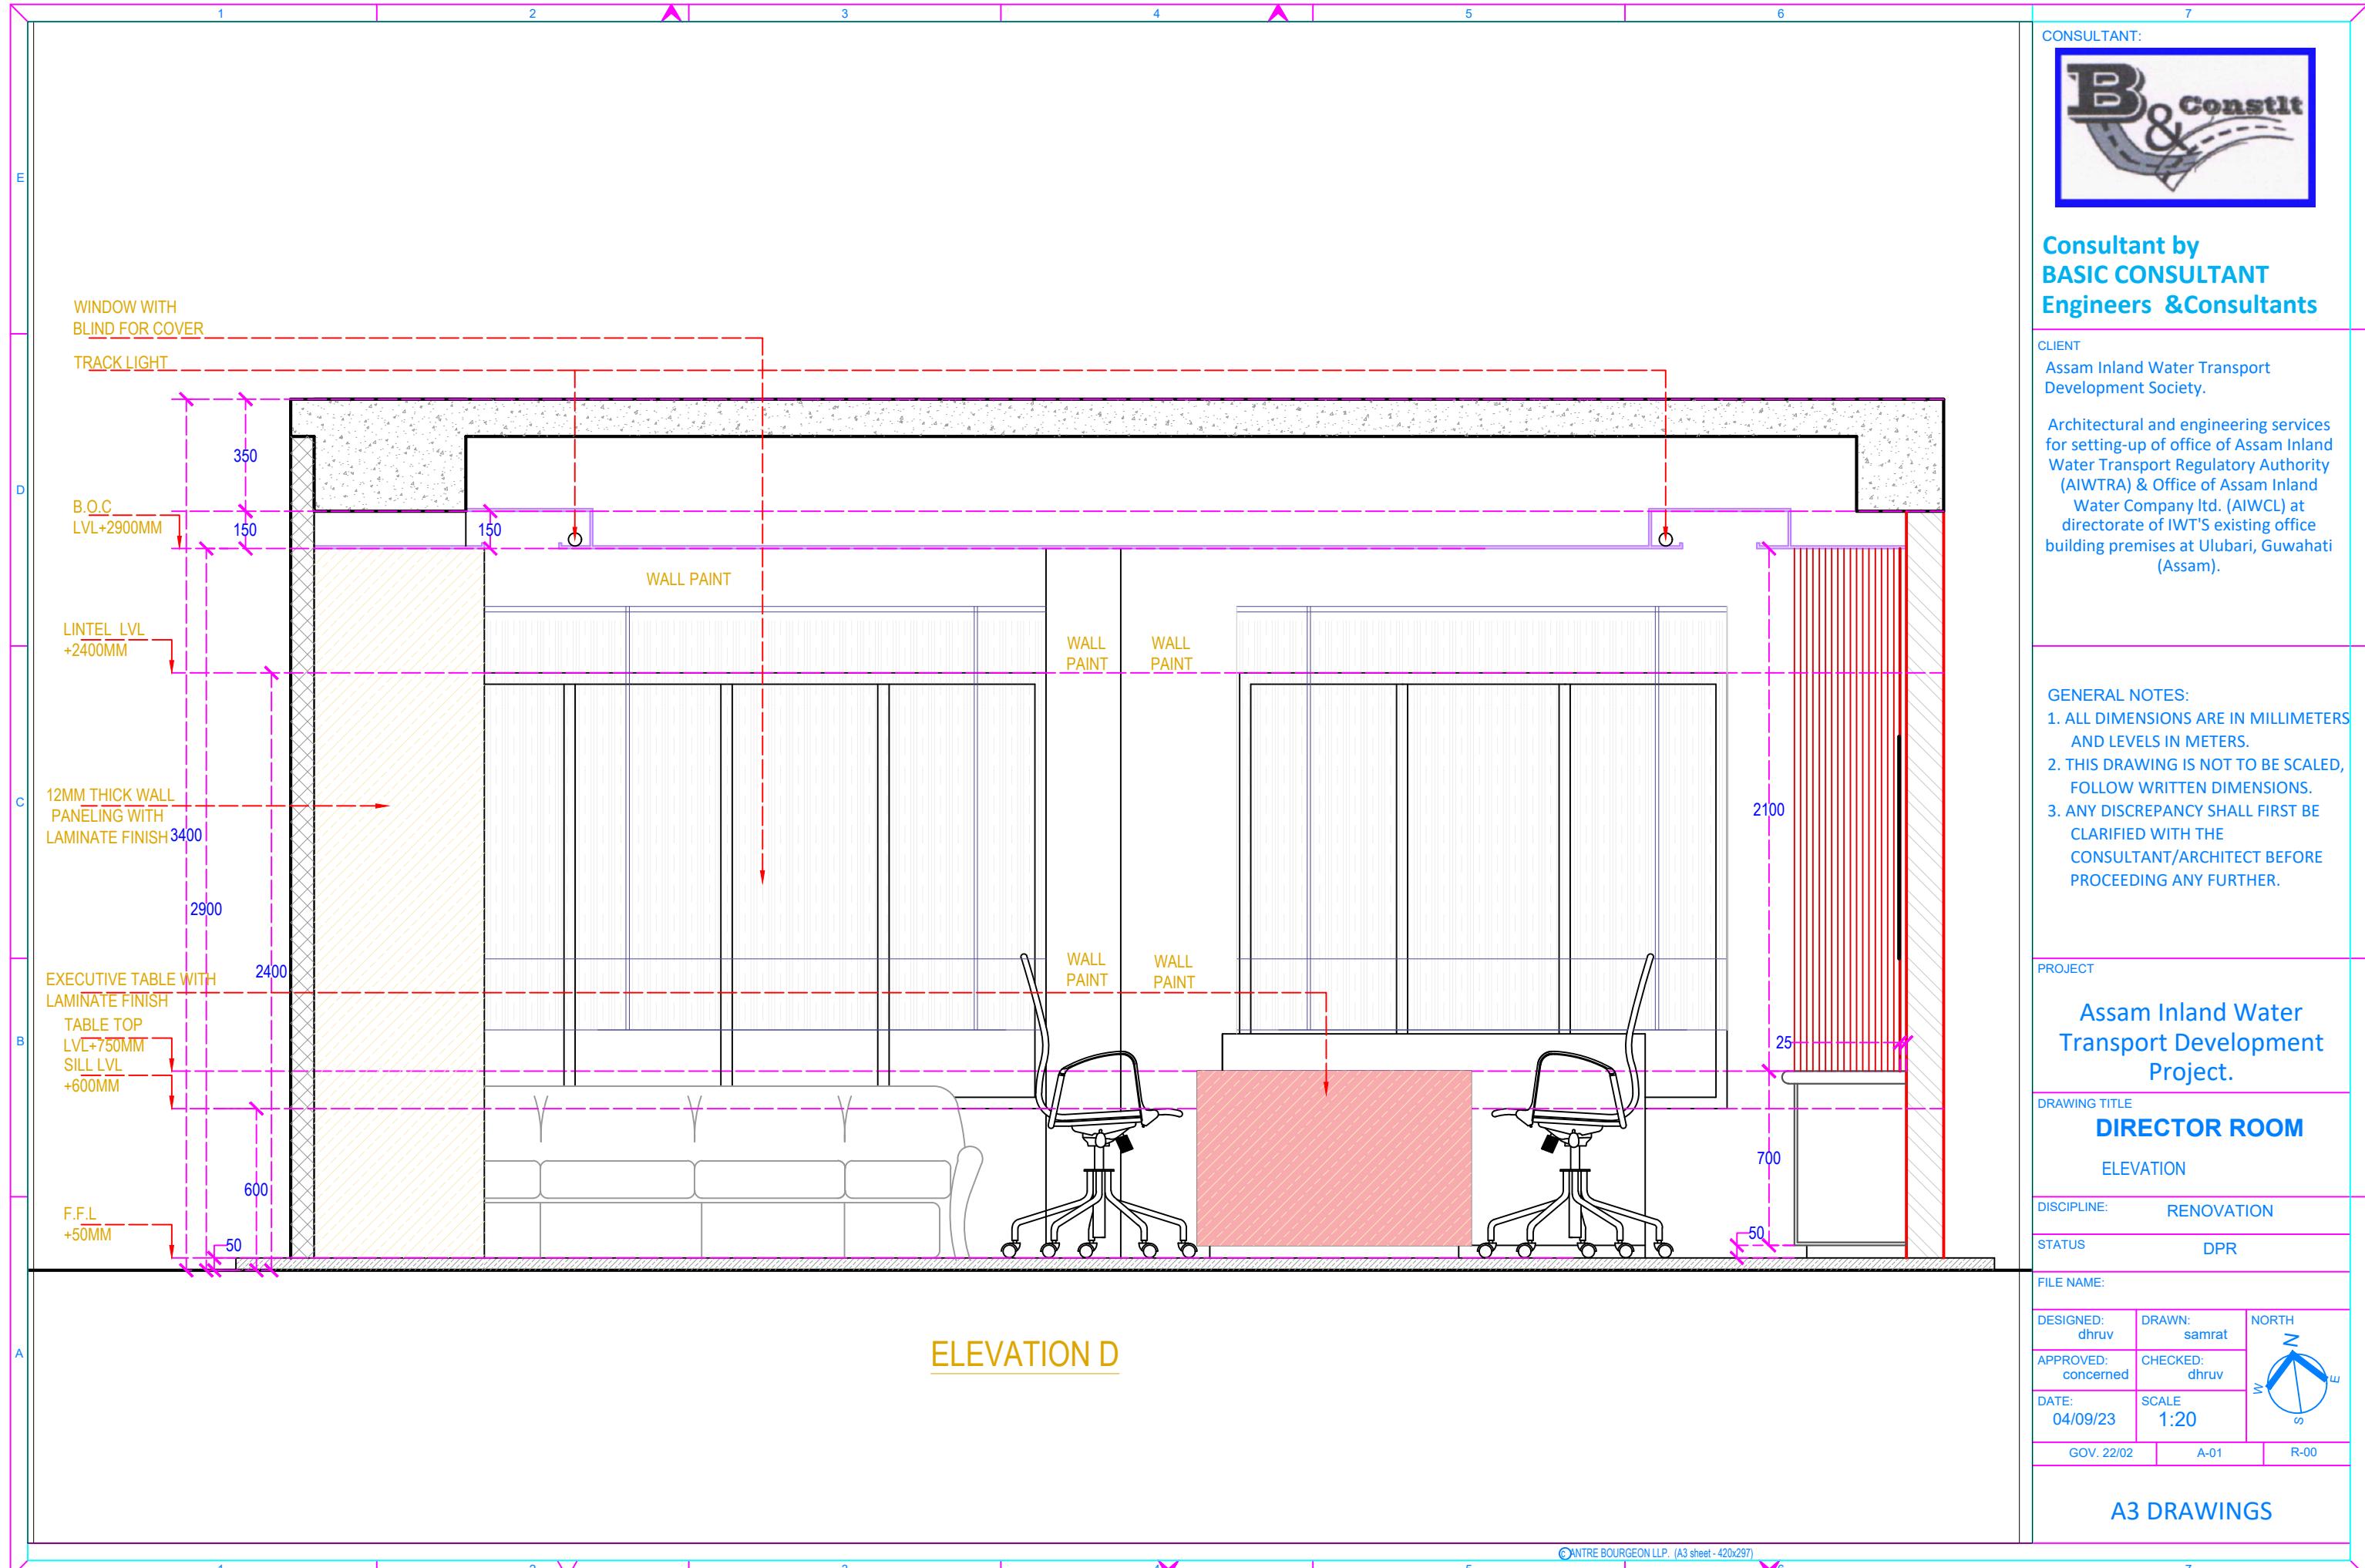



1	2	3	4	5	6	7
E		A		A		E
D						D
C						C
B						B
A						A
EXISTING PLAN						CONSULTANT:
						
						Consultant by BASIC CONSULTANT Engineers & Consultants
						CLIENT Assam Inland Water Transport Development Society.
						Architectural and engineering services for setting-up of office of Assam Inland Water Transport Regulatory Authority (AIWTRA) & Office of Assam Inland Water Company Ltd. (AIWCL) at directorate of IWT'S existing office building premises at Ulubari, Guwahati (Assam).
						GENERAL NOTES: 1. ALL DIMENSIONS ARE IN MILLIMETERS AND LEVELS IN METERS. 2. THIS DRAWING IS NOT TO BE SCALED, FOLLOW WRITTEN DIMENSIONS. 3. ANY DISCREPANCY SHALL FIRST BE CLARIFIED WITH THE CONSULTANT/ARCHITECT BEFORE PROCEEDING ANY FURTHER.
						PROJECT Assam Inland Water Transport Development Project.
						DRAWING TITLE TERRACE EXISTING PLAN
						DISCIPLINE: RENOVATION
						STATUS DPR
						FILE NAME:
						DESIGNED: dhruv DRAWN: samrat NORTH APPROVED: concerned CHECKED: dhruv DATE: 30/08/23 SCALE 1:15 GOV. 22/02 A-01 R-00
						A1 DRAWINGS
1	2	3	4	5	6	7
V	V	V	V	V	V	

1	2	3	4	5	6	7
E		A		A		E
D						D
C						C
B						B
A						A
DEMOLISHING PLAN						CONSULTANT:
						
						Consultant by BASIC CONSULTANT Engineers & Consultants
						CLIENT Assam Inland Water Transport Development Society.
						Architectural and engineering services for setting-up of office of Assam Inland Water Transport Regulatory Authority (AIWTRA) & Office of Assam Inland Water Company Ltd. (AIWCL) at directorate of IWT'S existing office building premises at Ulubari, Guwahati (Assam).
						GENERAL NOTES: 1. ALL DIMENSIONS ARE IN MILLIMETERS AND LEVELS IN METERS. 2. THIS DRAWING IS NOT TO BE SCALED, FOLLOW WRITTEN DIMENSIONS. 3. ANY DISCREPANCY SHALL FIRST BE CLARIFIED WITH THE CONSULTANT/ARCHITECT BEFORE PROCEEDING ANY FURTHER.
						PROJECT Assam Inland Water Transport Development Project.
						DRAWING TITLE TEERRACE DEMOLISHING EXISTING PLAN
						DISCIPLINE: RENOVATION
						STATUS DPR
						FILE NAME:
						DESIGNED: drhuv DRAWN: samrat NORTH APPROVED: concerned CHECKED: drhuv DATE: 30/08/23 SCALE 1:15 GOV. 22/02 A-01 R-00
						A1 DRAWINGS
						© ANTRÉ BOURGEON LLP. (A3 sheet - 420x297)
1	2	3	4	5	6	7
V	V	V	V	V	V	

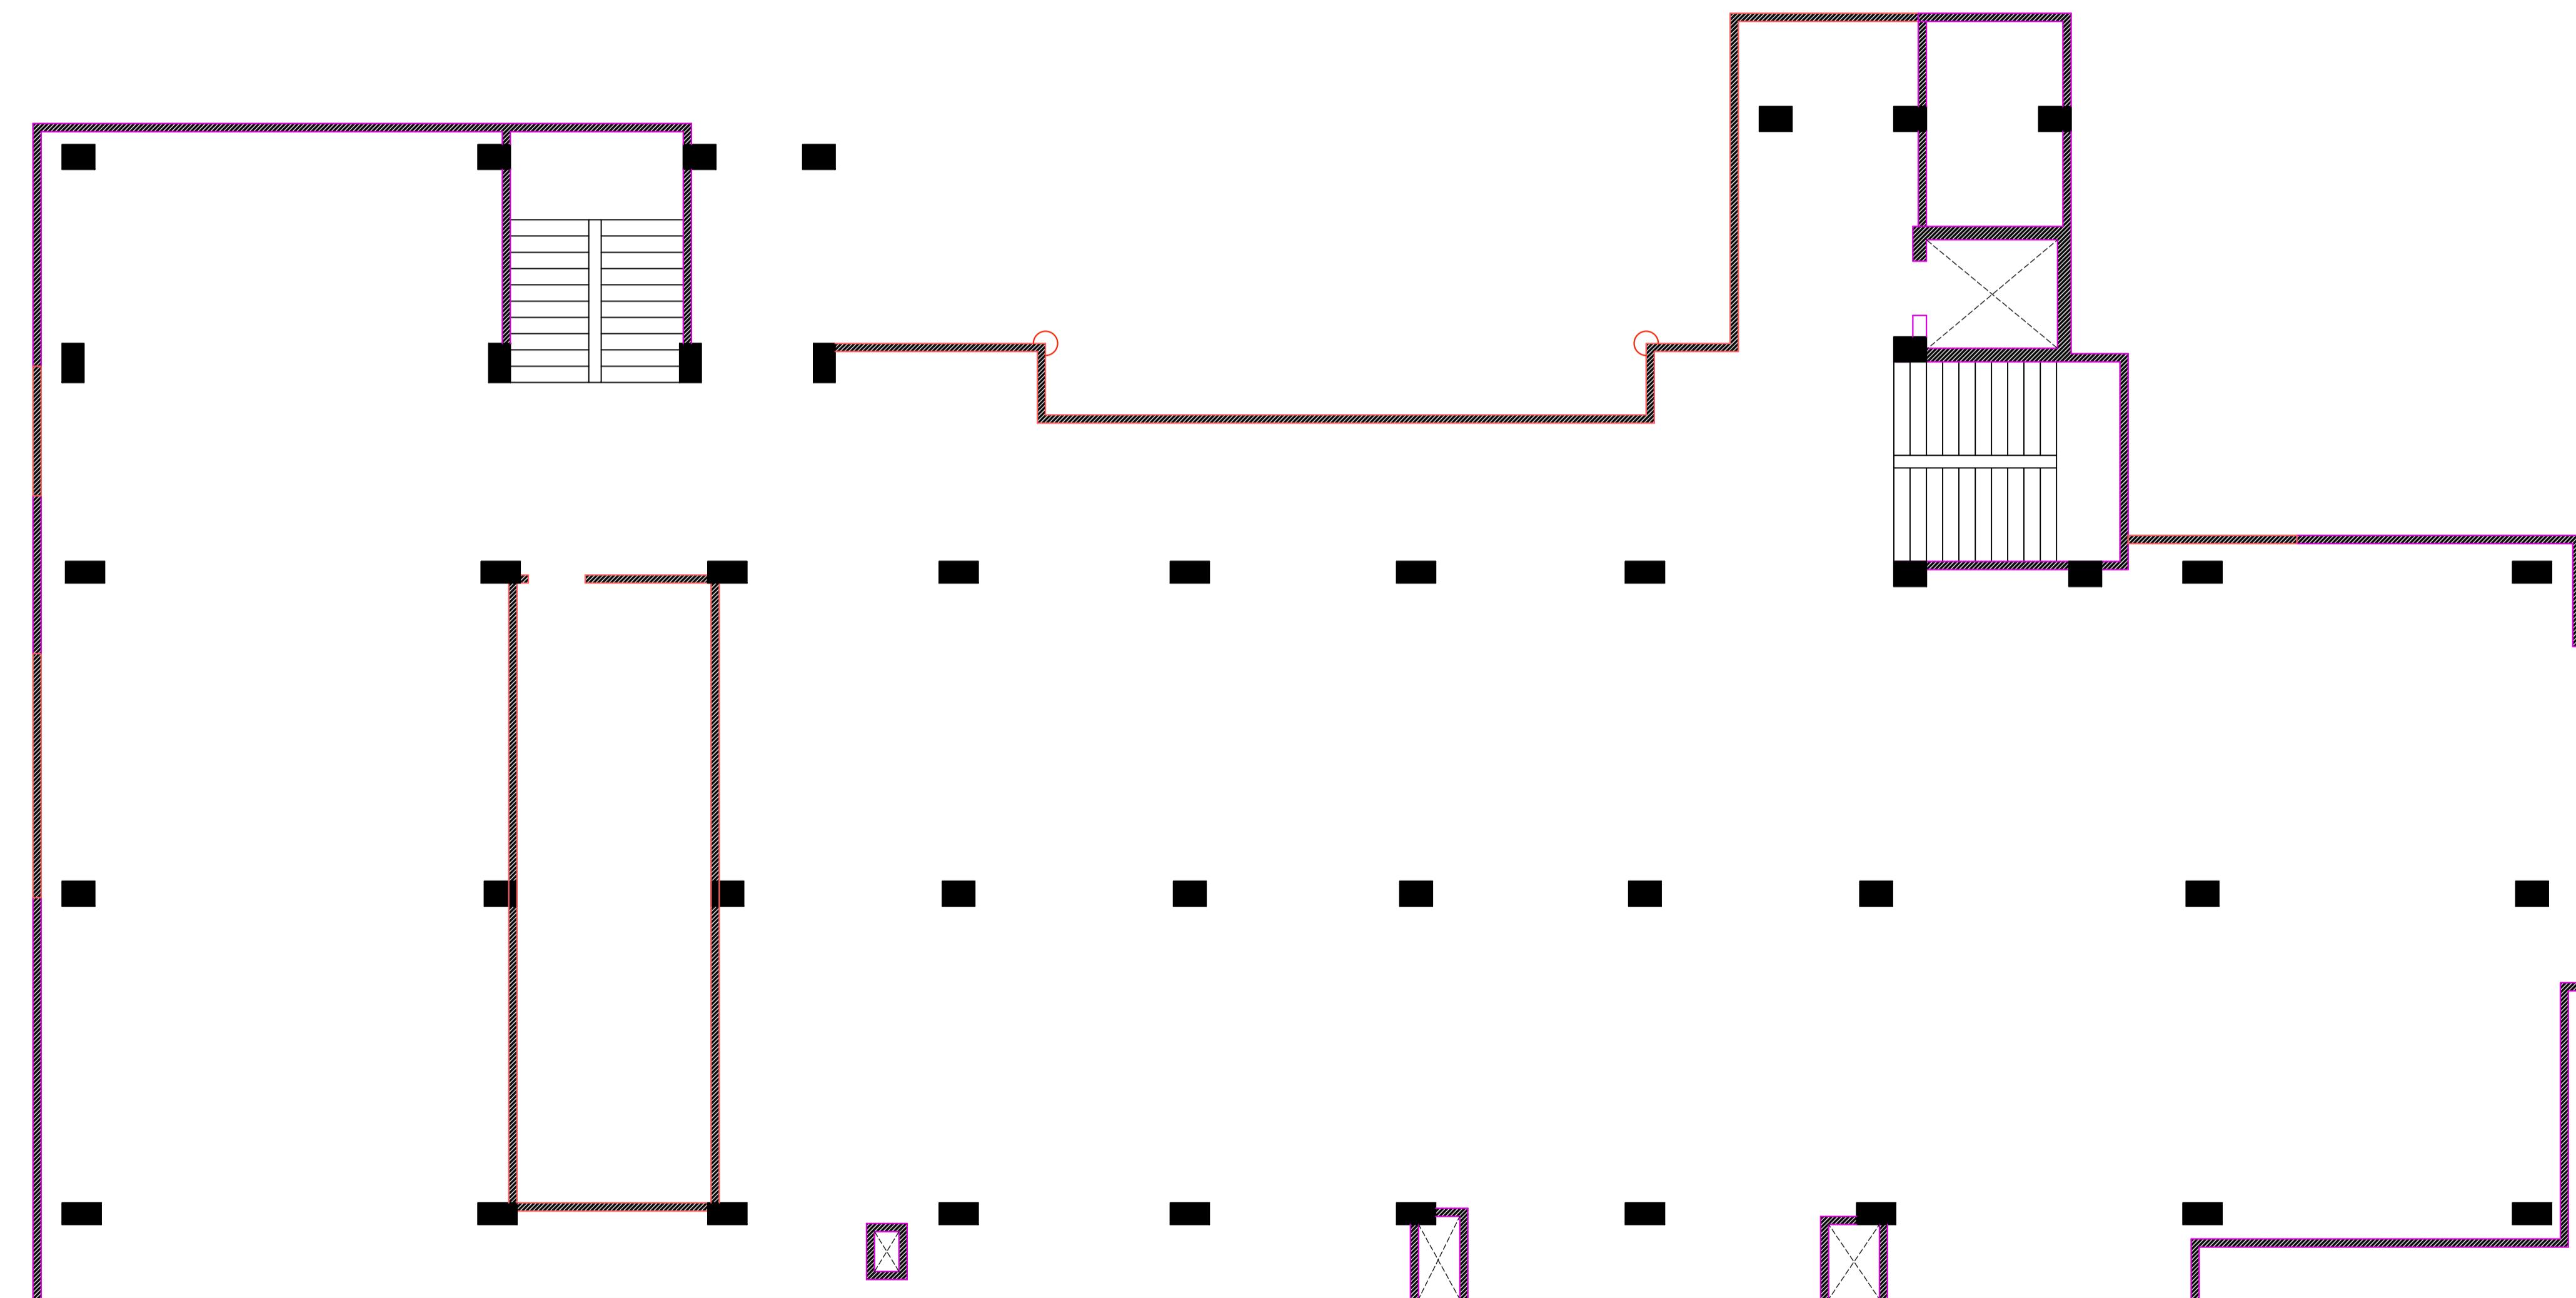

	LEGEND :	
	DEMOLISHING WALLS	
	EXISTING WALLS	
	RCC COLUMN	

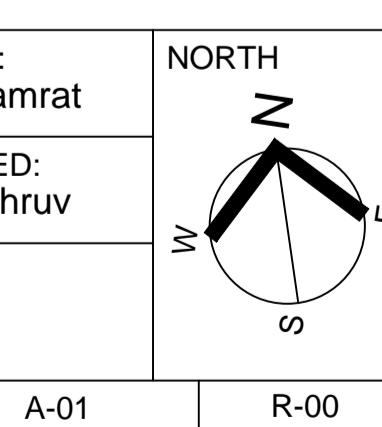

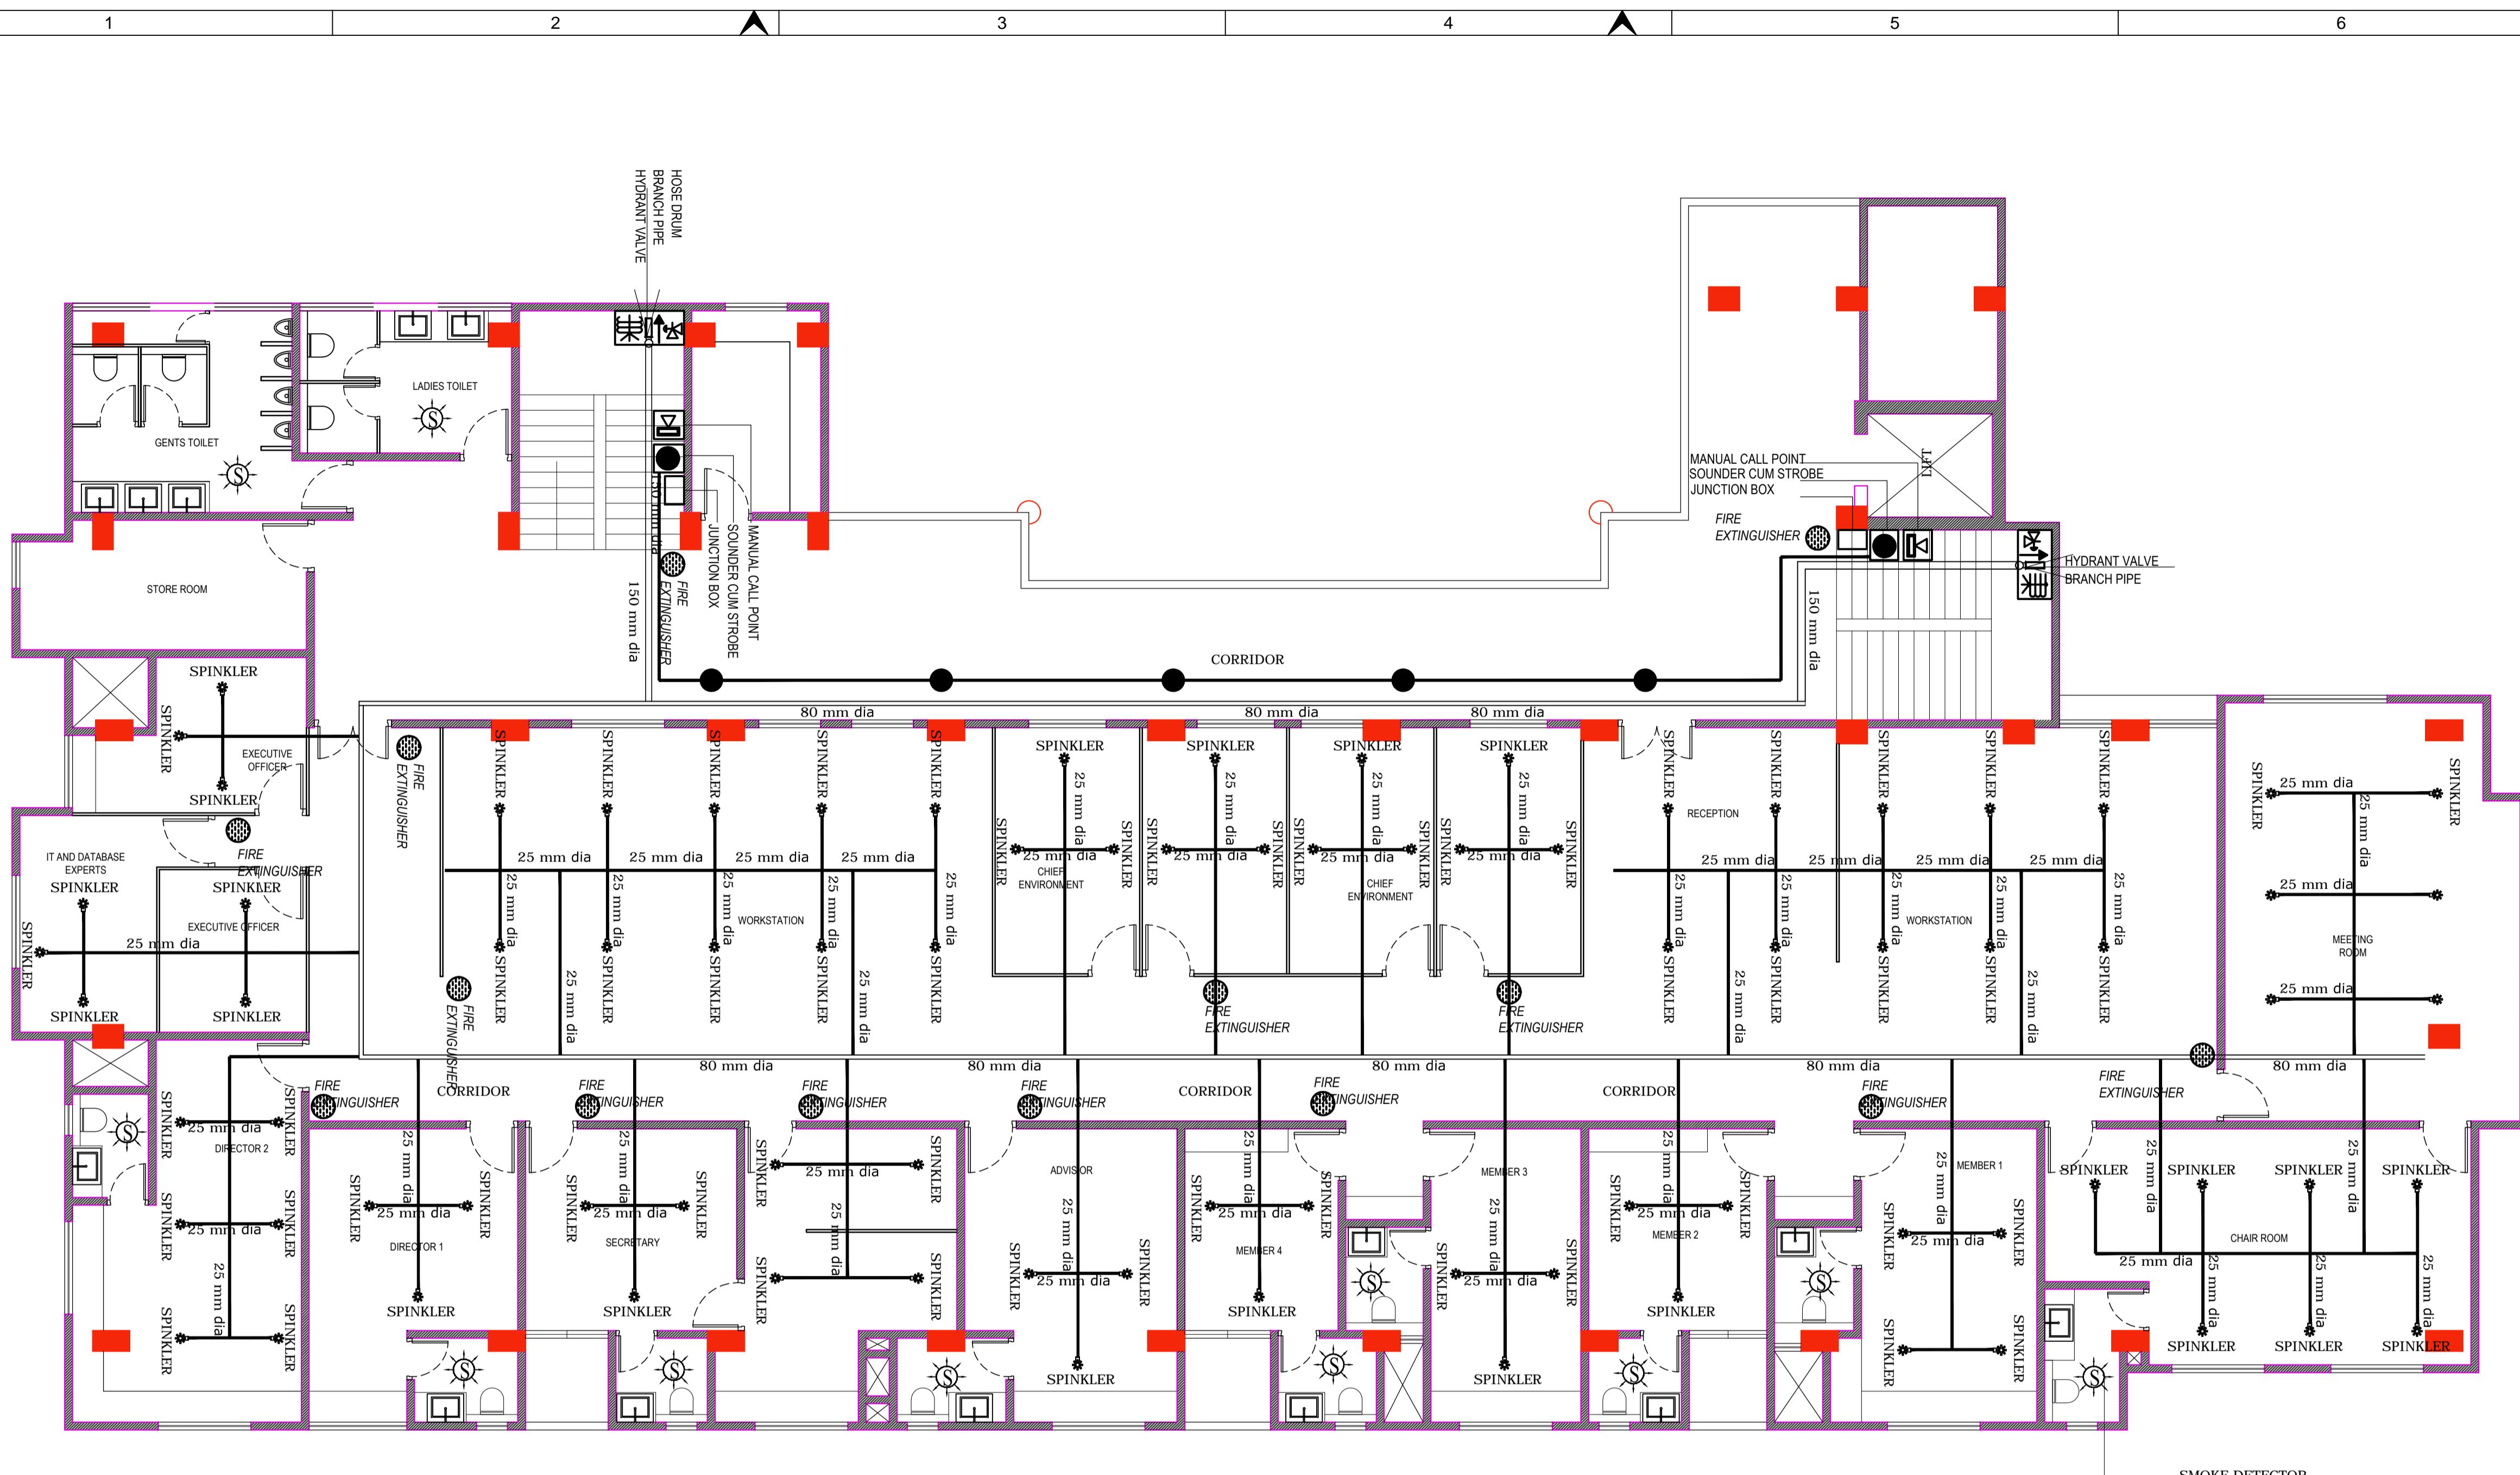

TERRACE FLOOR

FIRE FIGTHING



**Consultant by
BASIC CONSULTANT
Engineers & Consultants**

CLIENT

Assam Inland Water Transport Development Society.

Architectural and engineering services for setting-up of office of Assam Inland Water Transport Regulatory Authority (AIWTRA) & Office of Assam Inland Water Company Ltd. (AIWCL) at directorate of IWT'S existing office building premises at Ulubari, Guwahati (Assam).

GENERAL NOTES:

1. ALL DIMENSIONS ARE IN MILLIMETERS AND LEVELS IN METERS.
2. THIS DRAWING IS NOT TO BE SCALED, FOLLOW WRITTEN DIMENSIONS.
3. ANY DISCREPANCY SHALL FIRST BE CLARIFIED WITH THE CONSULTANT/ARCHITECT BEFORE PROCEEDING ANY FURTHER.


PROJECT
Assam Inland Water Transport Development Project.

DRAWING TITLE
TERRACE FLOOR
FIRE FIGTHING

DISCIPLINE: RENOVATION



STATUS DPR

FILE NAME:

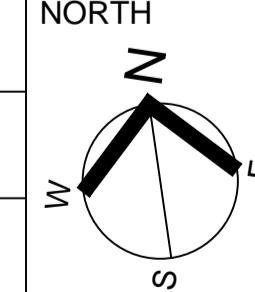DESIGNED:	dhruv	DRAWN:	samrat	NORTH 
APPROVED:	concerned	CHECKED:	dhruv	
DATE:	30/08/23	SCALE	1:15	

GOV. 22/02 A-01 R-00

A1 DRAWINGS

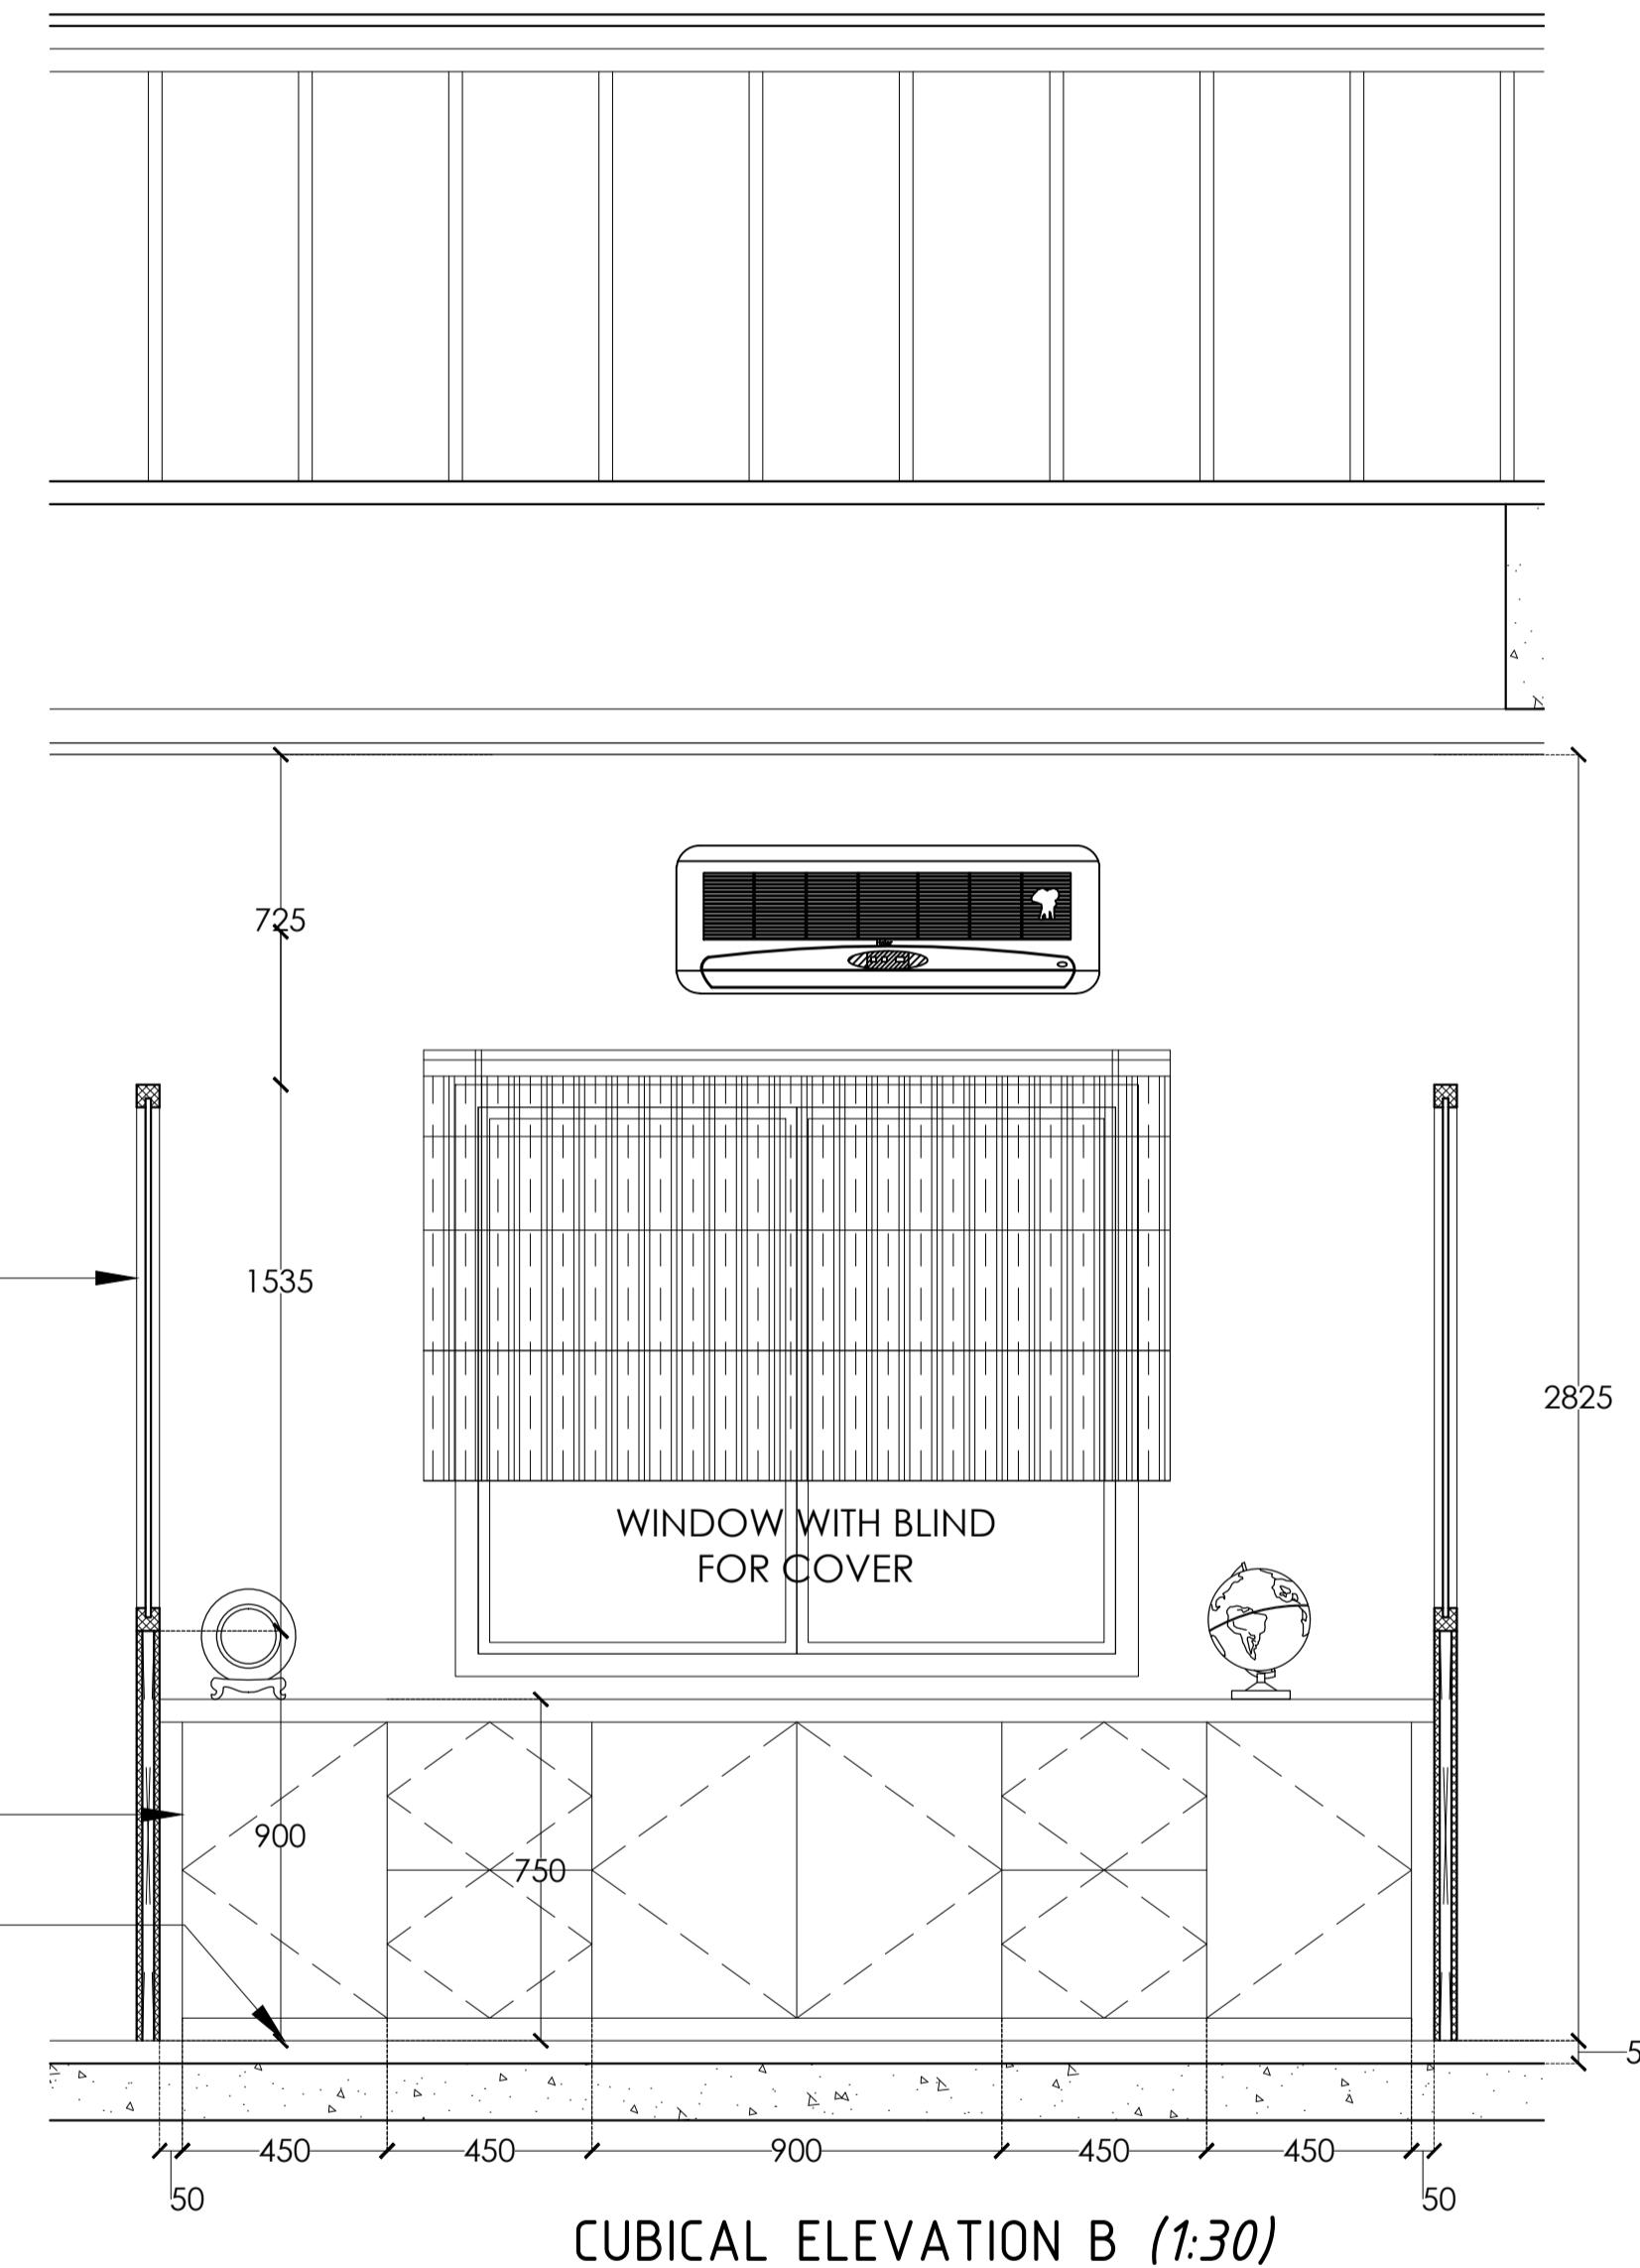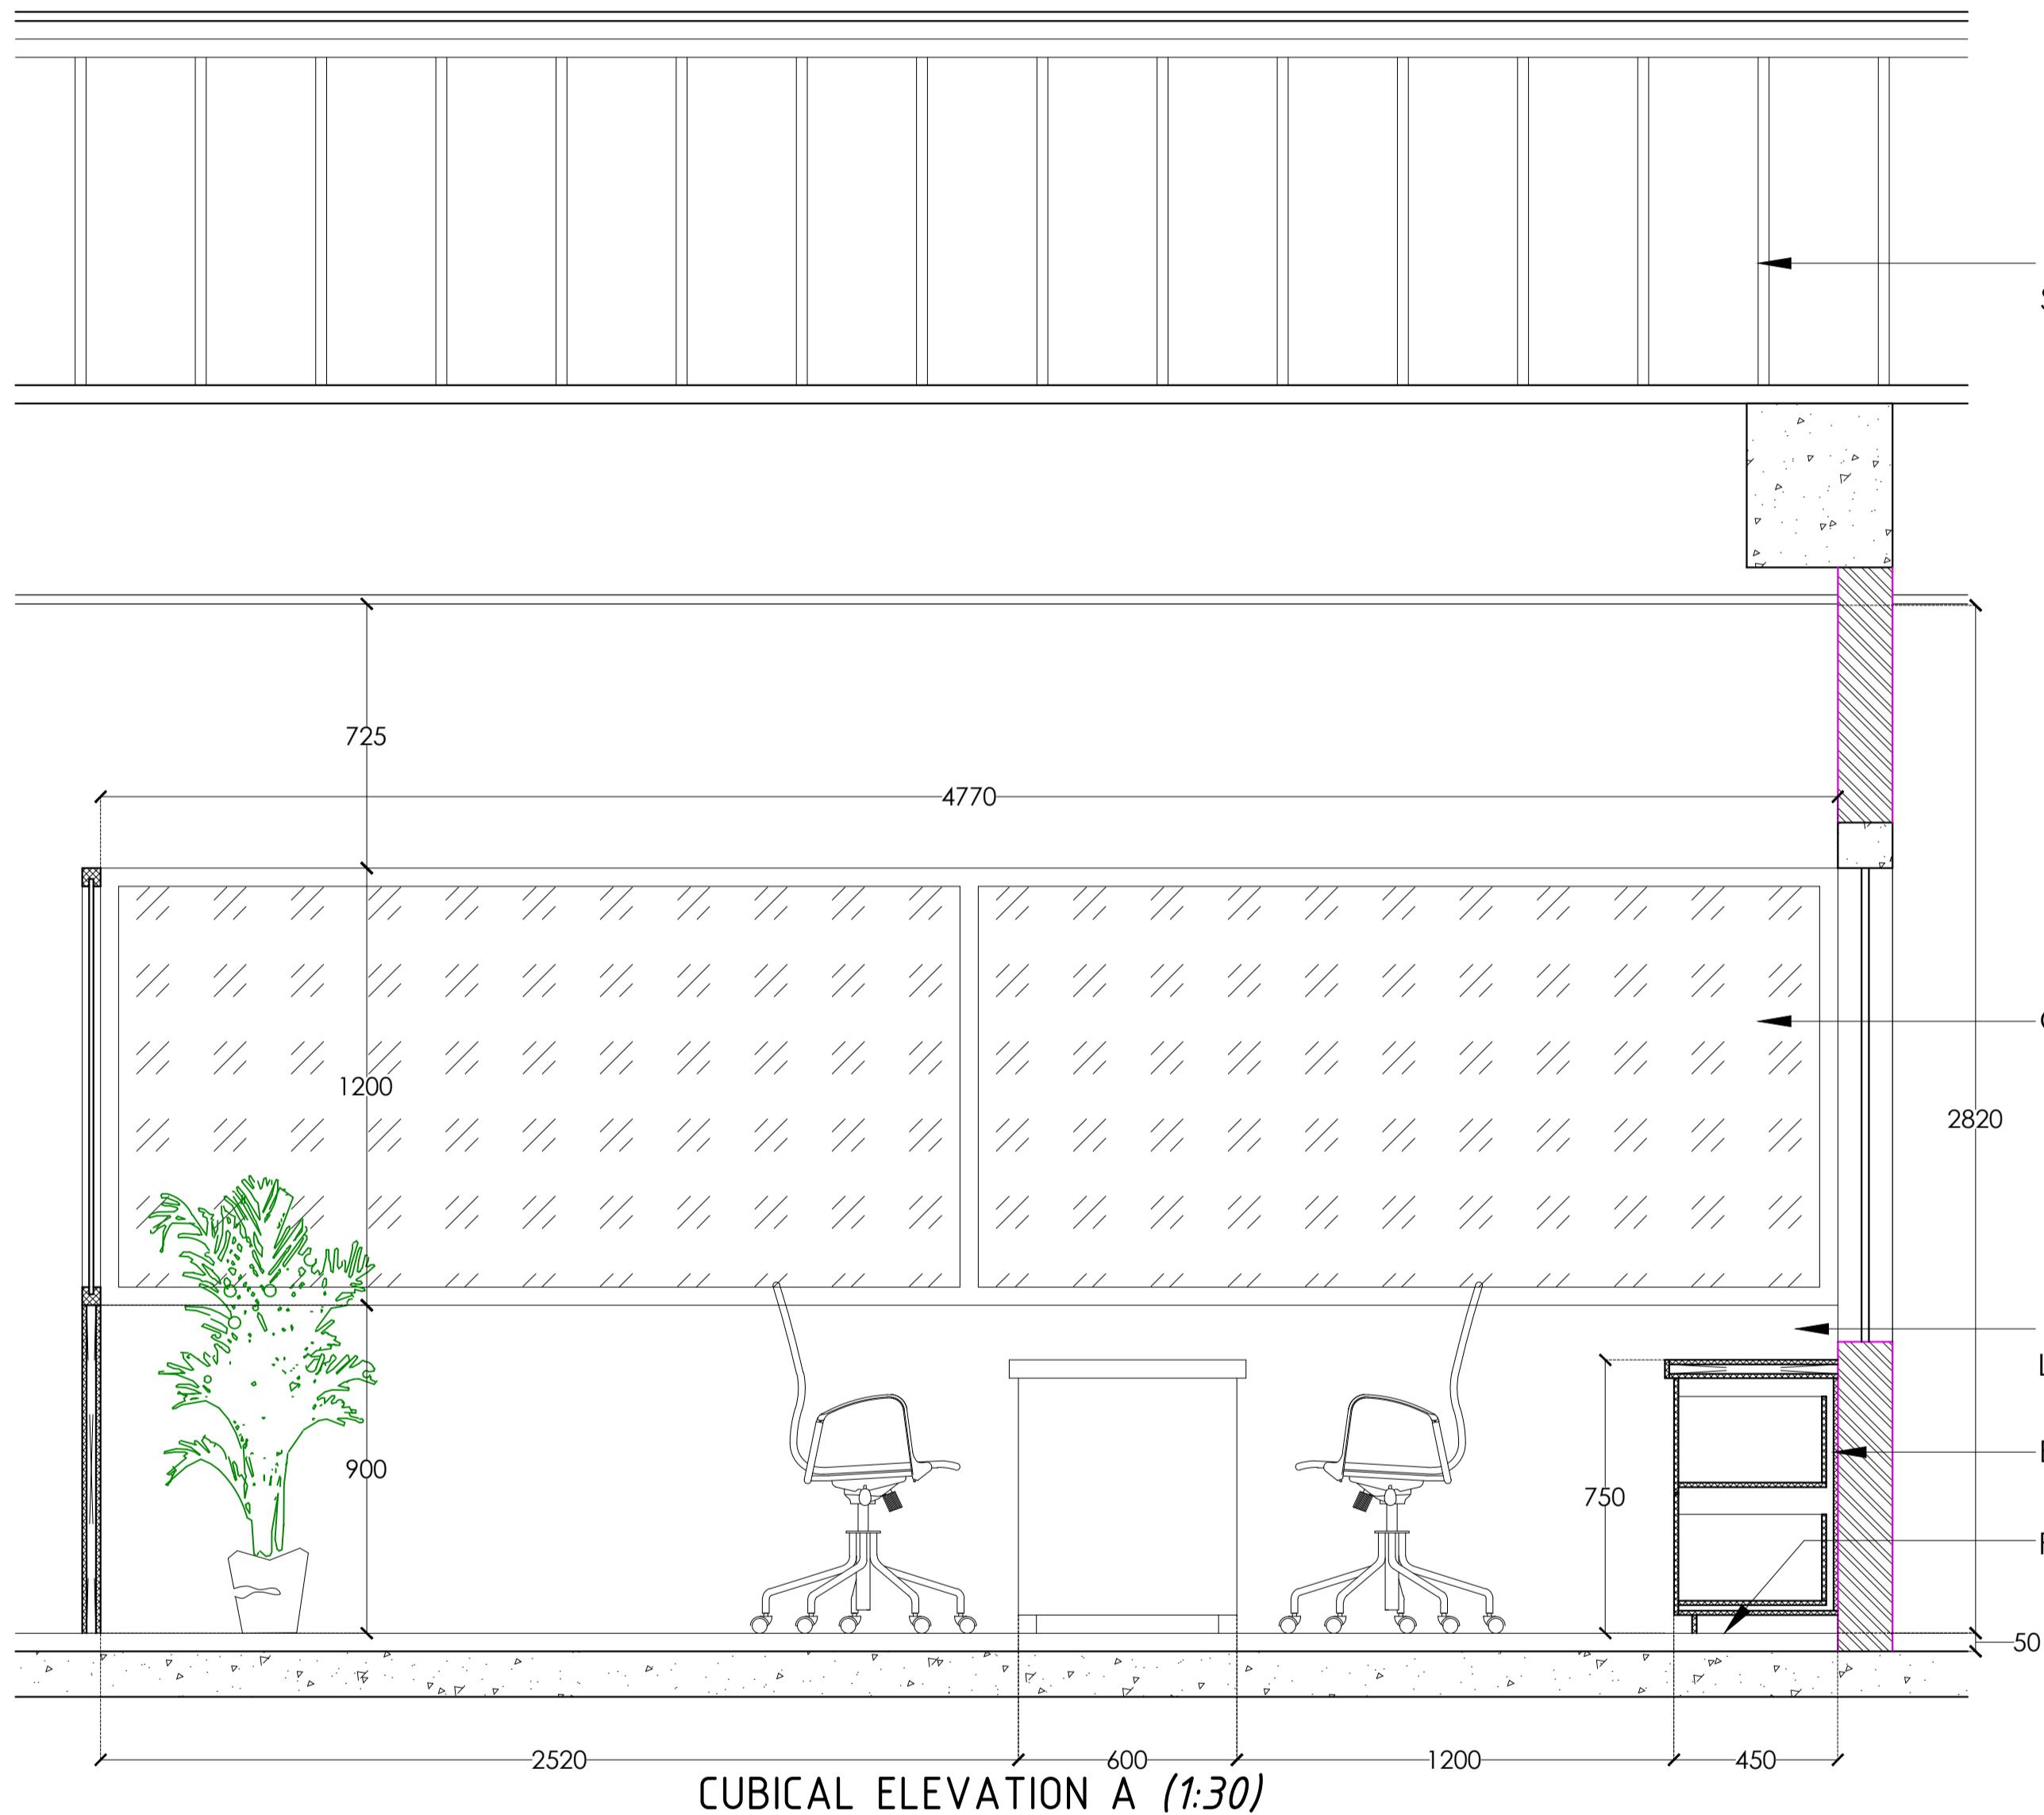

Consultant by
BASIC CONSULTANT
Engineers & Consultants

CLIENT
Assam Inland Water Transport Development Society.
Architectural and engineering services for setting-up of office of Assam Inland Water Transport Regulatory Authority (AIWTRA) & Office of Assam Inland Water Company Ltd. (AIWCL) at directorate of IWT'S existing office building premises at Ulubari, Guwahati (Assam).

GENERAL NOTES:
1. ALL DIMENSIONS ARE IN MILLIMETERS AND LEVELS IN METERS.
2. THIS DRAWING IS NOT TO BE SCALED, FOLLOW WRITTEN DIMENSIONS.
3. ANY DISCREPANCY SHALL FIRST BE CLARIFIED WITH THE CONSULTANT/ARCHITECT BEFORE PROCEEDING ANY FURTHER.

PROJECT
Assam Inland Water Transport Development Project.

DRAWING TITLE
CUBICLE DETAILS

DISCIPLINE: RENOVATION

STATUS DPR

FILE NAME:

DESIGNED: dhruv	DRAWN: samrat	NORTH
APPROVED: concerned	CHECKED: dhruv	
DATE: 30/08/23	SCALE 1:30	

GOV. 22/02	A-01	R-00
------------	------	------

A1 DRAWINGS

